


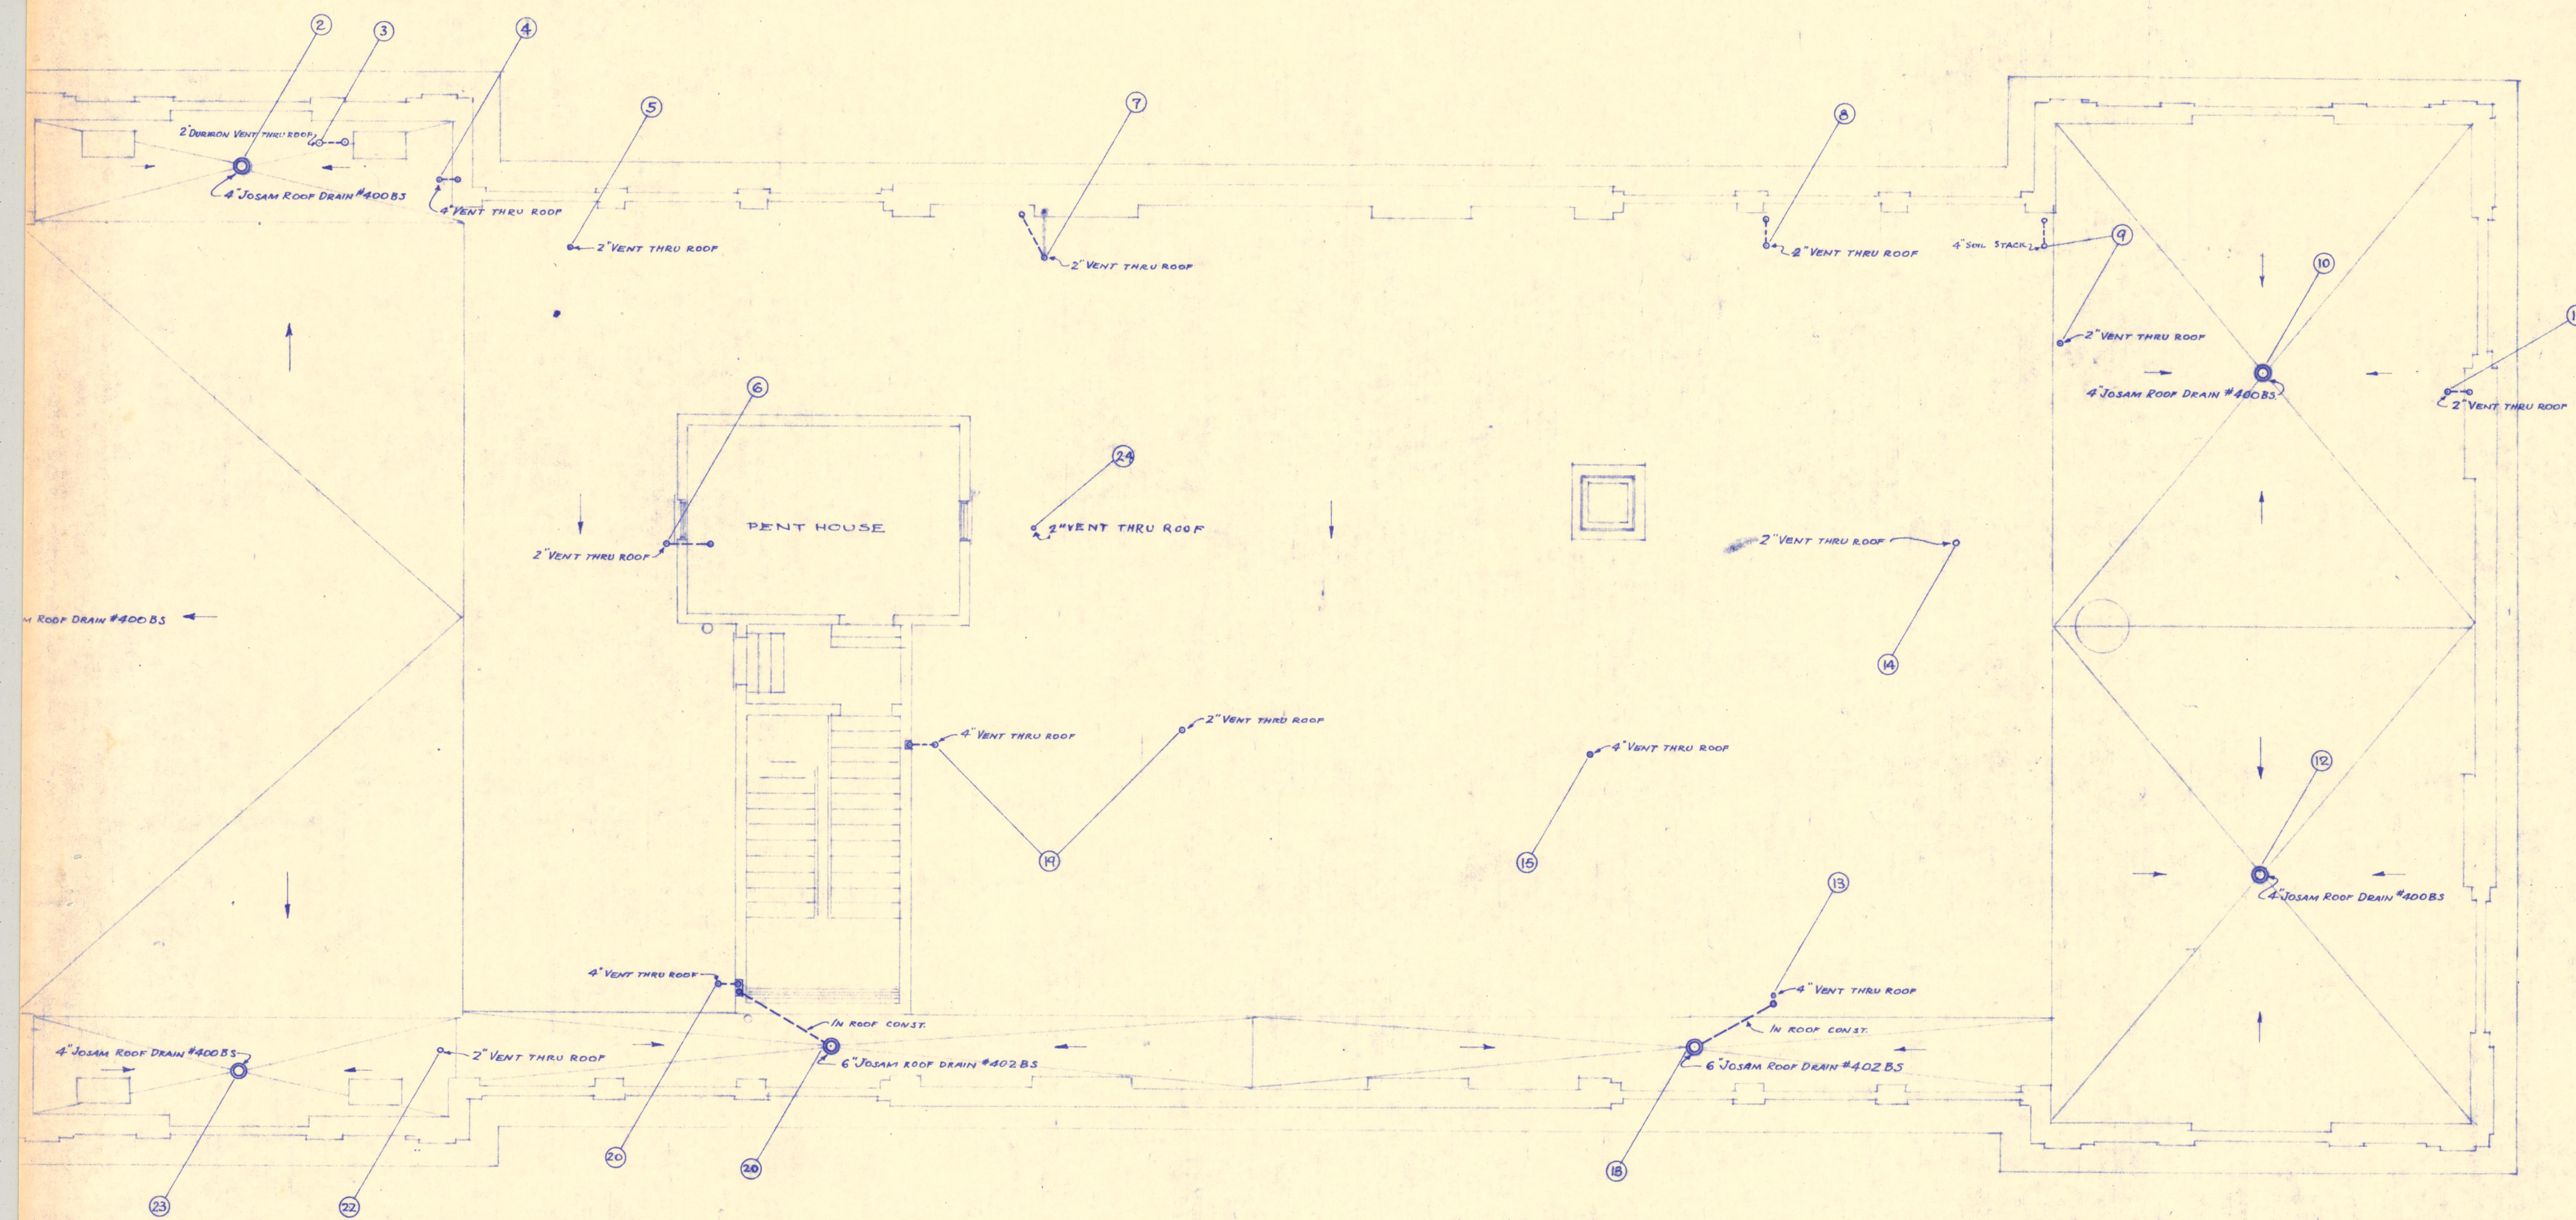

SCALE 1/8"=1'-0"
 ROOF PLAN

PLUMBING AND DRAINAGE

~ CITY HALL ~
 ST. JOSEPH, MISSOURI.

DATE
 JUNE 22, 1925
 ECKEL AND ALDRICH
 ARCHITECTS
 ST. JOSEPH, MO. LOS ANGELES

SHEET
 306

2007. 33. 4219 D