


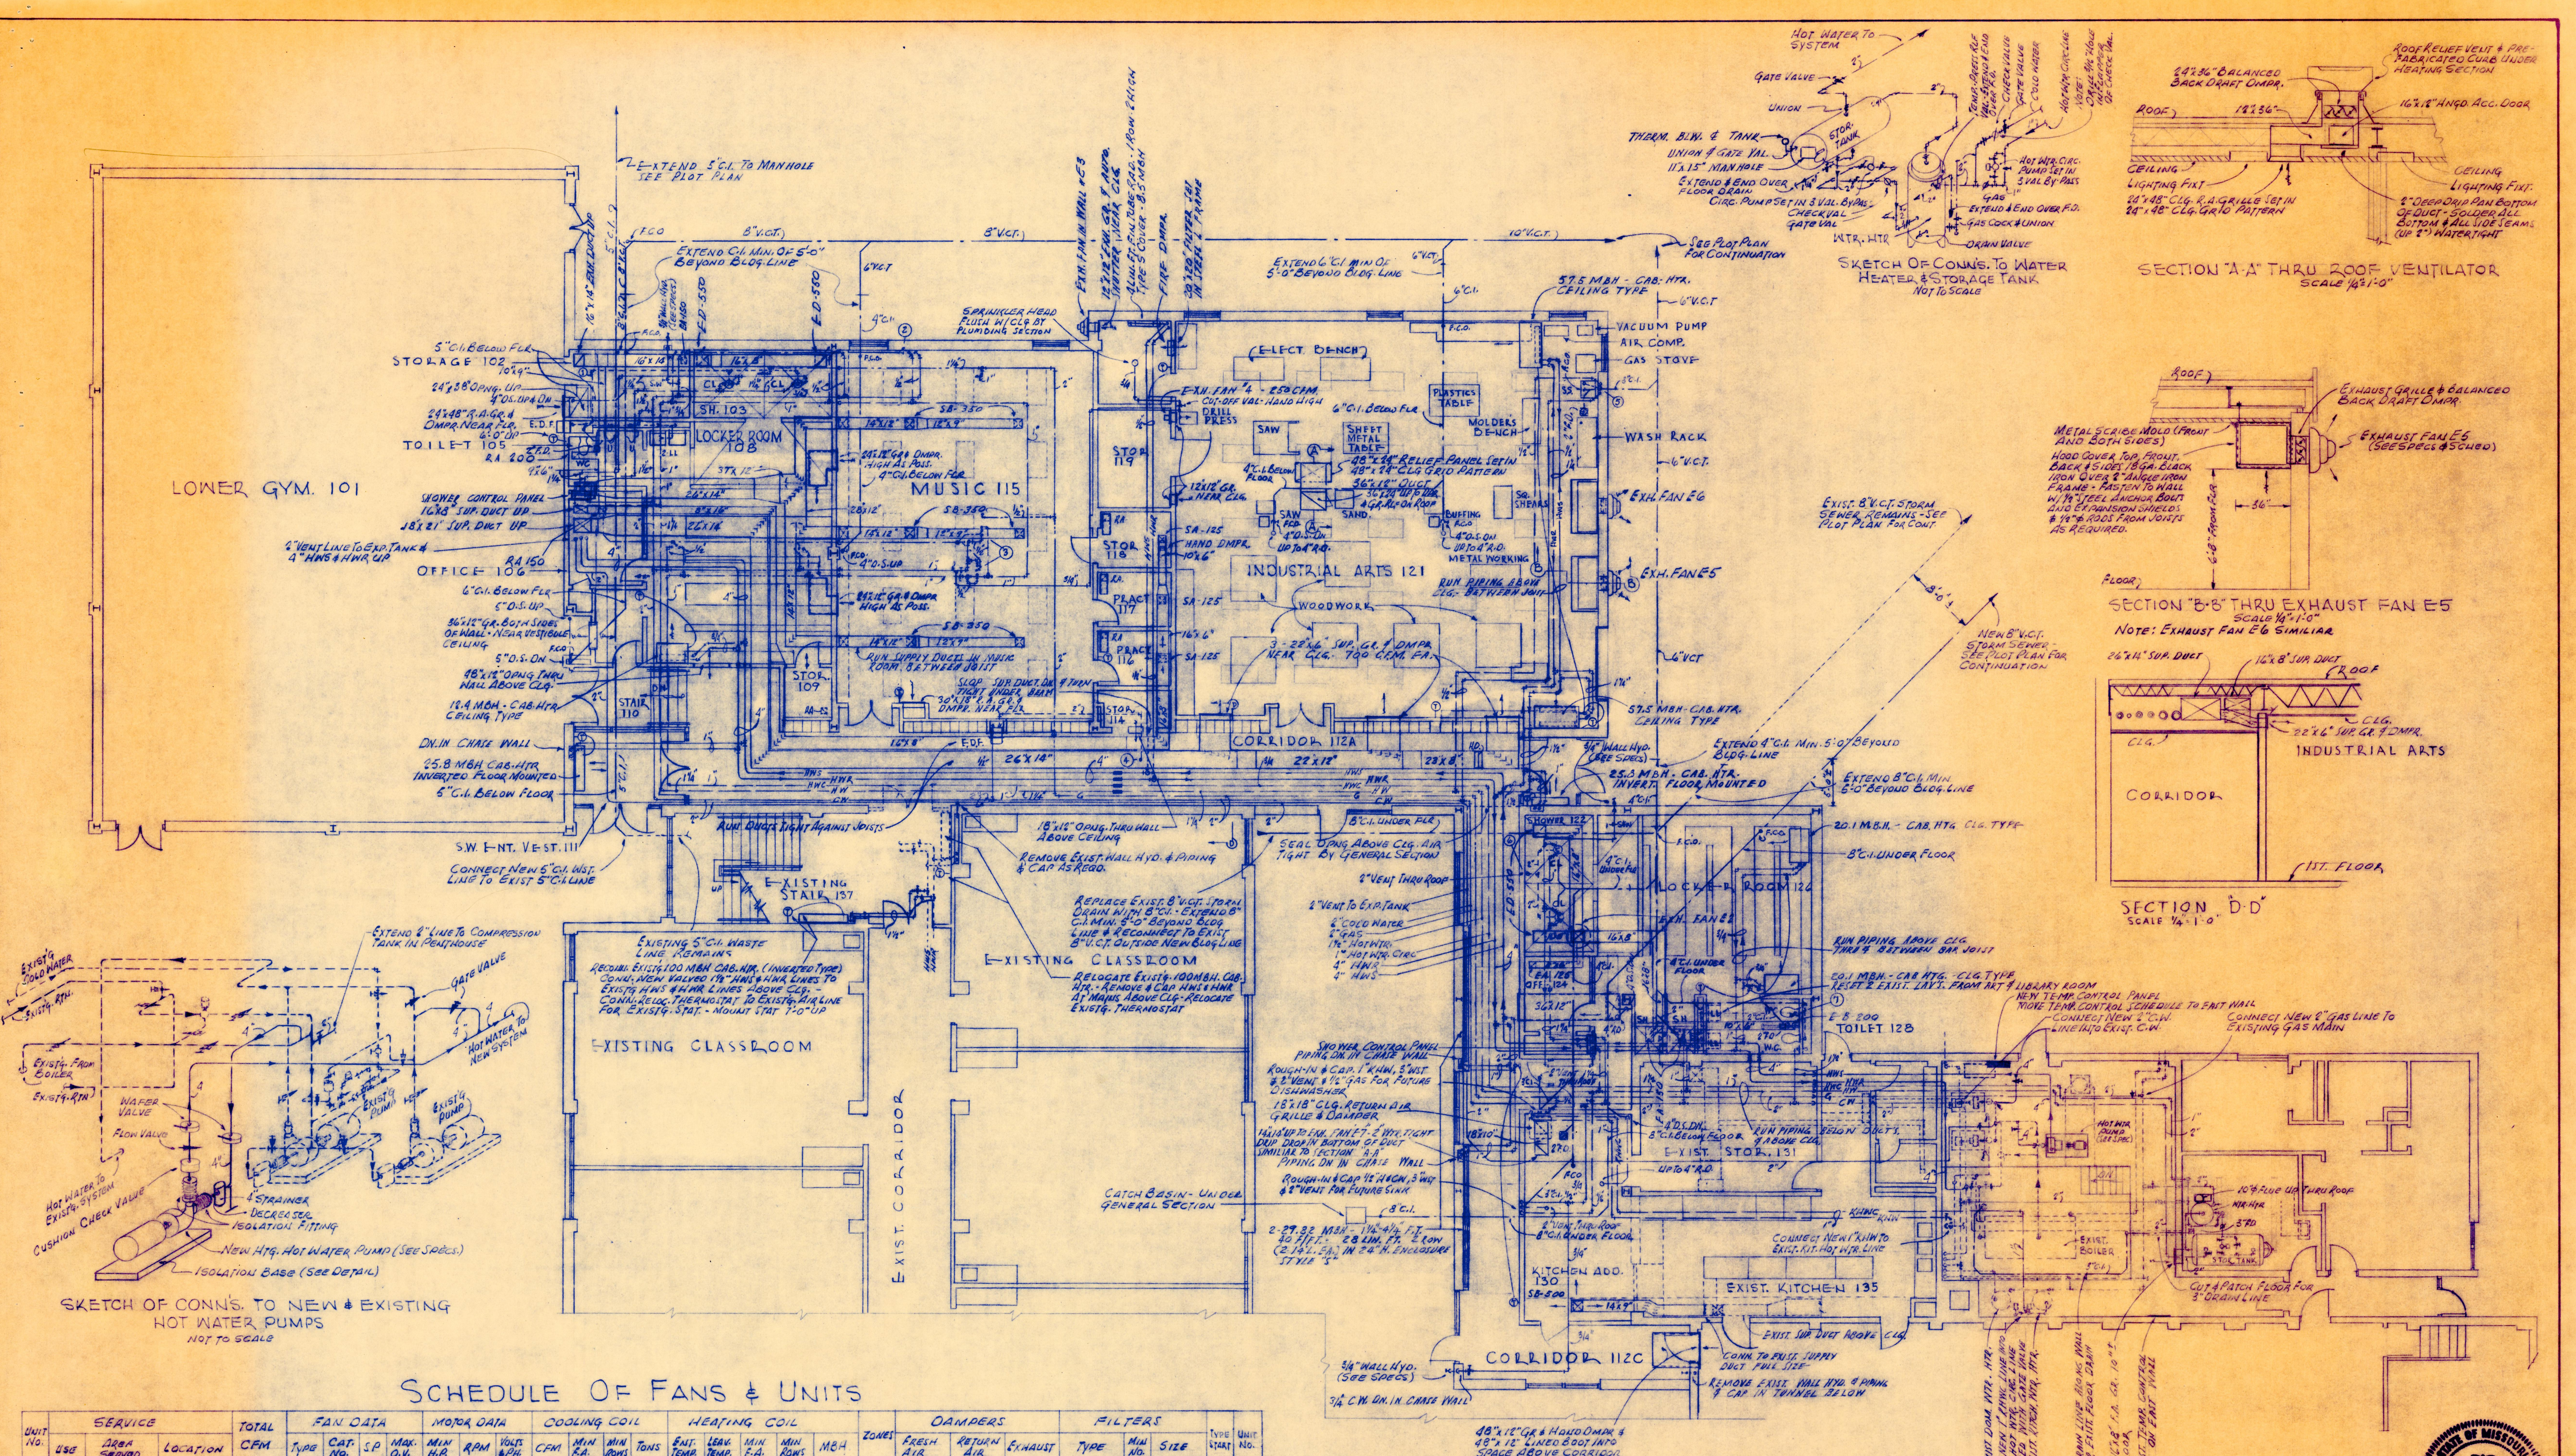

SCHEDULE OF FANS & UNITS


UNIT NO.	SERVICE	TOTAL CFM	FAN DATA			MOTOR DATA			COOLING COIL			HEATING COIL			DAMPERS			FILTERS			TYPE	UNIT NO.
			TYPE	SP. NO.	SP. INCH	HP	HP	HP	HP	HP	HP	HP	HP	HP	HP	HP	HP	HP	HP	HP		
51	SUP GYM	8020	ROOF	180	1/2	1/2	1/2	1/2	1/2	1/2	1/2	1/2	1/2	1/2	1/2	1/2	1/2	1/2	1/2	1/2	1/2	1/2
52	SUP CLASSROOMS	9025	ROOF	180	1/2	1/2	1/2	1/2	1/2	1/2	1/2	1/2	1/2	1/2	1/2	1/2	1/2	1/2	1/2	1/2	1/2	1/2
53	EXH BOILER ROOM	1000	ROOF	180	1/2	1/2	1/2	1/2	1/2	1/2	1/2	1/2	1/2	1/2	1/2	1/2	1/2	1/2	1/2	1/2	1/2	1/2
54	EXH INDUSTRIAL ARTS	250	WALL	180	1/2	1/2	1/2	1/2	1/2	1/2	1/2	1/2	1/2	1/2	1/2	1/2	1/2	1/2	1/2	1/2	1/2	1/2
55	EXH INDUSTRIAL ARTS	1250	WALL	180	1/2	1/2	1/2	1/2	1/2	1/2	1/2	1/2	1/2	1/2	1/2	1/2	1/2	1/2	1/2	1/2	1/2	1/2
56	EXH INDUSTRIAL ARTS	1250	WALL	180	1/2	1/2	1/2	1/2	1/2	1/2	1/2	1/2	1/2	1/2	1/2	1/2	1/2	1/2	1/2	1/2	1/2	1/2
57	EXH KITCHEN ADD	840	ROOF	180	1/2	1/2	1/2	1/2	1/2	1/2	1/2	1/2	1/2	1/2	1/2	1/2	1/2	1/2	1/2	1/2	1/2	1/2
58	EXH PENHOUSE	1500	ROOF	180	1/2	1/2	1/2	1/2	1/2	1/2	1/2	1/2	1/2	1/2	1/2	1/2	1/2	1/2	1/2	1/2	1/2	1/2

* INDICATES ELECT. DAMPER ** EXPLOSION PROOF MOTOR A- INDICATES MAGNETIC STARTER
 • INDICATES MARLO COIL CO. ▼ INDICATES VENT-AIR CORD B- INDICATES MANUAL THERMAL OVERLOAD SWITCH W/ALUM. LIGHT (FLUSH MTD. - EXCEPT IN PHASE)

FIRST FLOOR PLAN
SCALE 1/8" = 1'-0"

NOTE
ALL MEASUREMENTS must be verified at building by the contractor before work indicated hereon is started.

W.L. CASSELL & ASSOCIATES, INC.
MECHANICAL & ELECTRICAL ENGINEERS
912 BALTIMORE AVENUE
KANSAS CITY, MISSOURI 64105

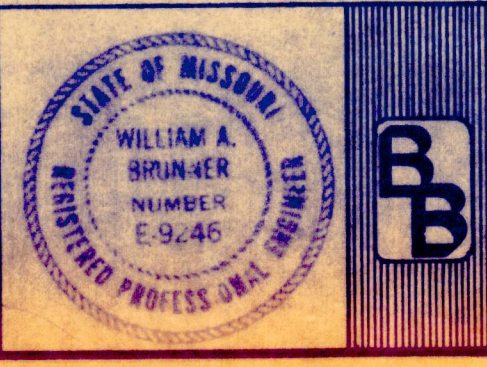

DRAWN BY P.A.M. CH'KD BY W.L.C.		ALTERATION AND ADDITION SPRING GARDEN MIDDLE SCHOOL		DATE 1-17-72
REVISION		5802 SOUTH 22nd STREET ST. JOSEPH, MISSOURI		JOB No.
BRUNNER & BRUNNER ARCHITECTS & ENGINEERS 1105 CORBY BUILDING 2007.33.2325,4		SCHOOL DISTRICT OF ST. JOSEPH, MO.		SHEET No. MS-1