



FURNACE & COIL SCHEDULE							
MARK	APT. SERVED	GAS INPUT BTU	COIL ARI CAP BTUH	CFM	FAN HP	MOTOR VOLTAGE	MANUFACTURER OR EQUAL
F-1	"B"	80,000	24,000	800	1/4	120/1/60	BRYANT
F-2	"A"	80,000	18,000	600	1/4	120/1/60	BRYANT
F-3	"S"	80,000	18,000	600	1/4	120/1/60	BRYANT

NOTE: FURNISH & INSTALL AIR COOLED CONDENSING UNIT TO MATCH ABOVE COIL COOLING CAPACITY ON ROOF. FURNISH & INSTALL VIBRATION ISOLATORS UNDER EACH CONDENSING UNIT. VOLTAGE FOR ALL CONDENSING UNITS 230/1/60, UNLESS OTHERWISE NOTED.



REGISTER & GRILLE SCHEDULE		
MARK	TYPE	MANUFACTURER & MODEL NO. OR EQUAL
R-1	S.A. REGISTER	HART & COOLEY NO. 661
R-2	S.A. REGISTER	HART & COOLEY NO. 411
R-3	S.A. REGISTER	
R-4		
G-1	RET. AIR GRILLE	HART & COOLEY NO. 650H
G-2		

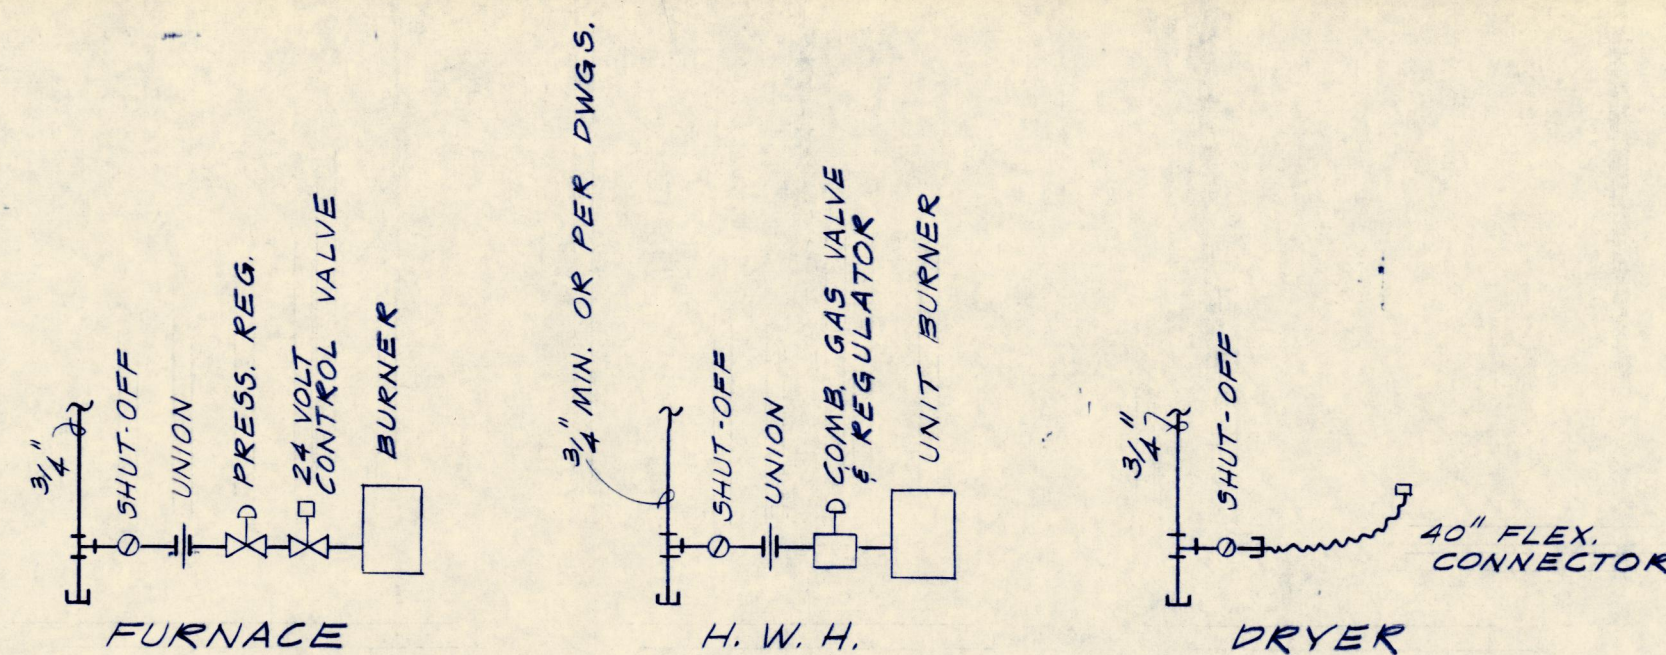



GAS CONNECTION DETAILS
NO SCALE

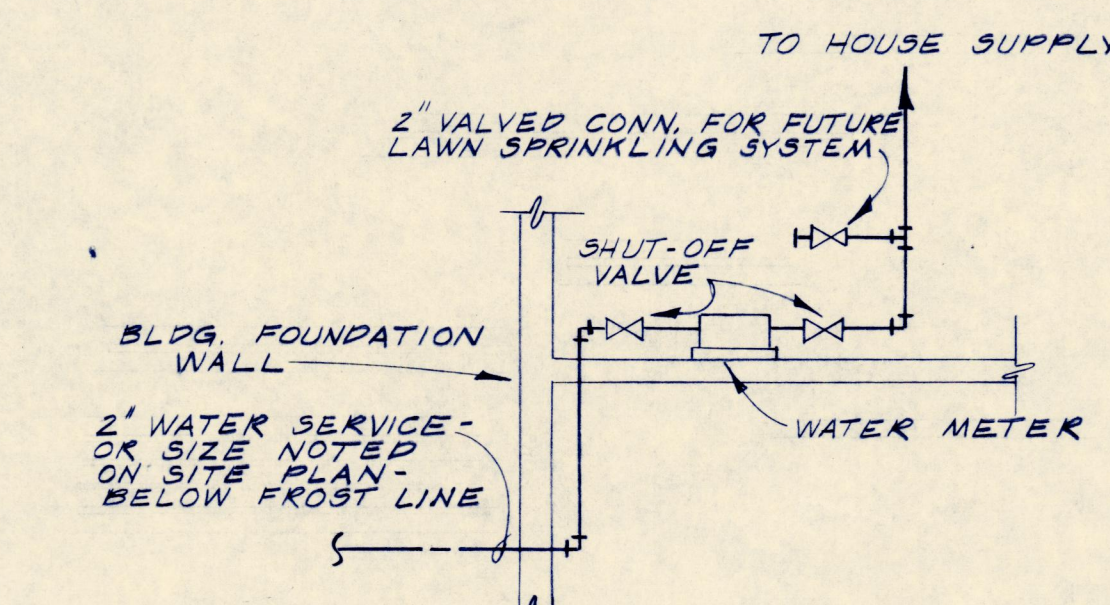


WATER SERVICE ENTRANCE DETAIL
NO SCALE

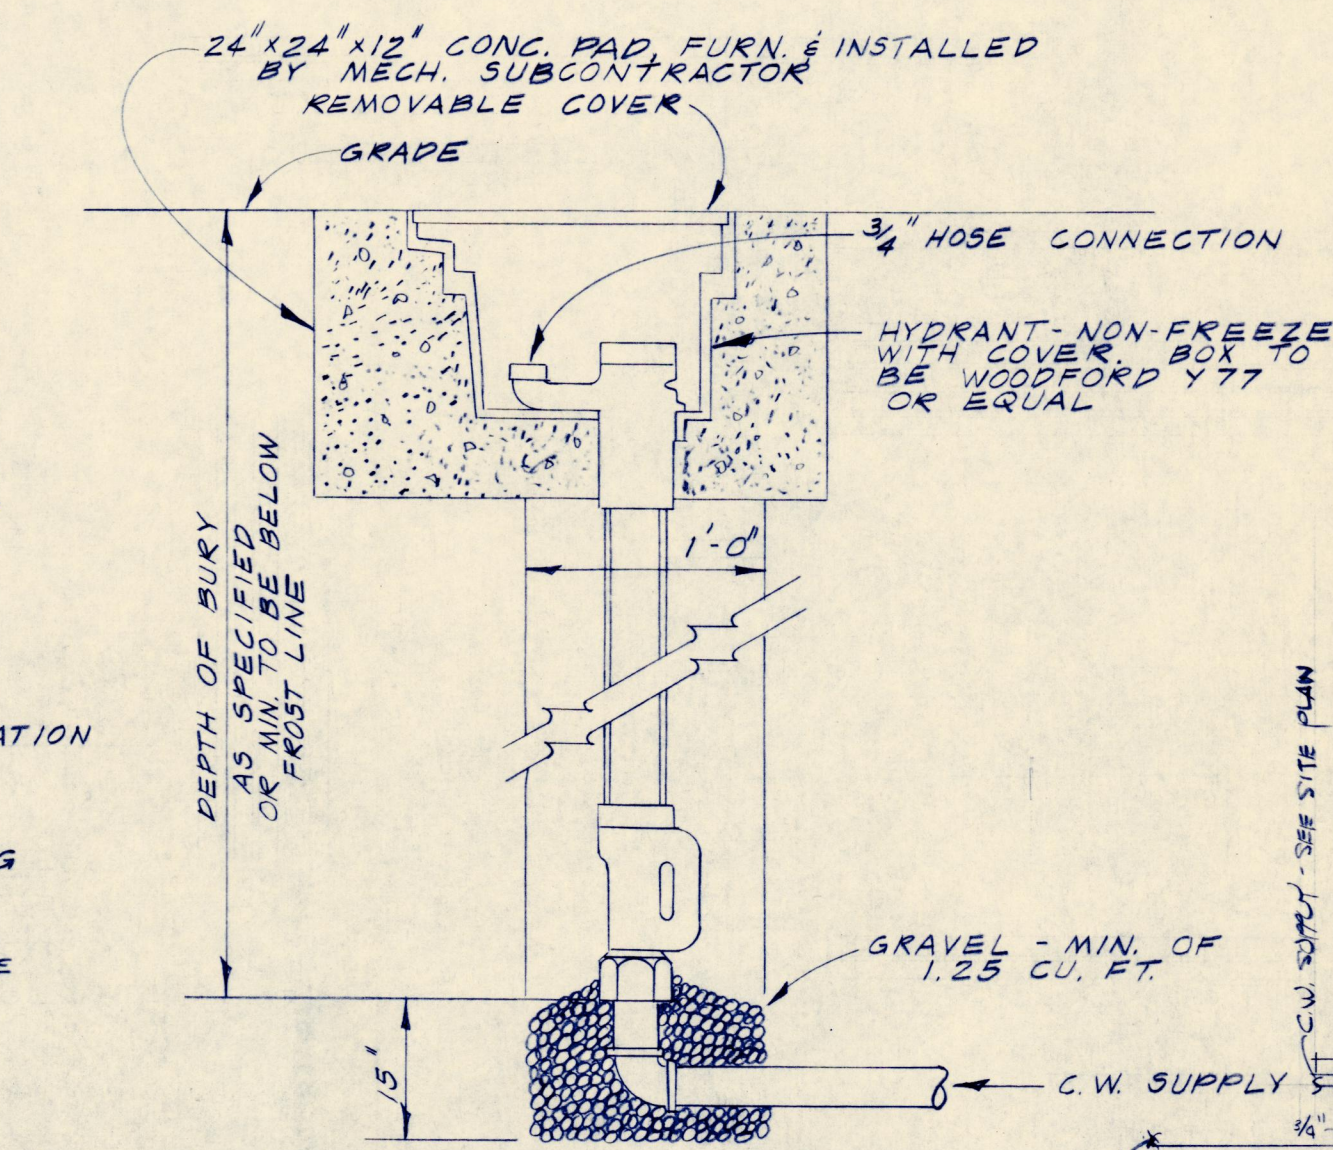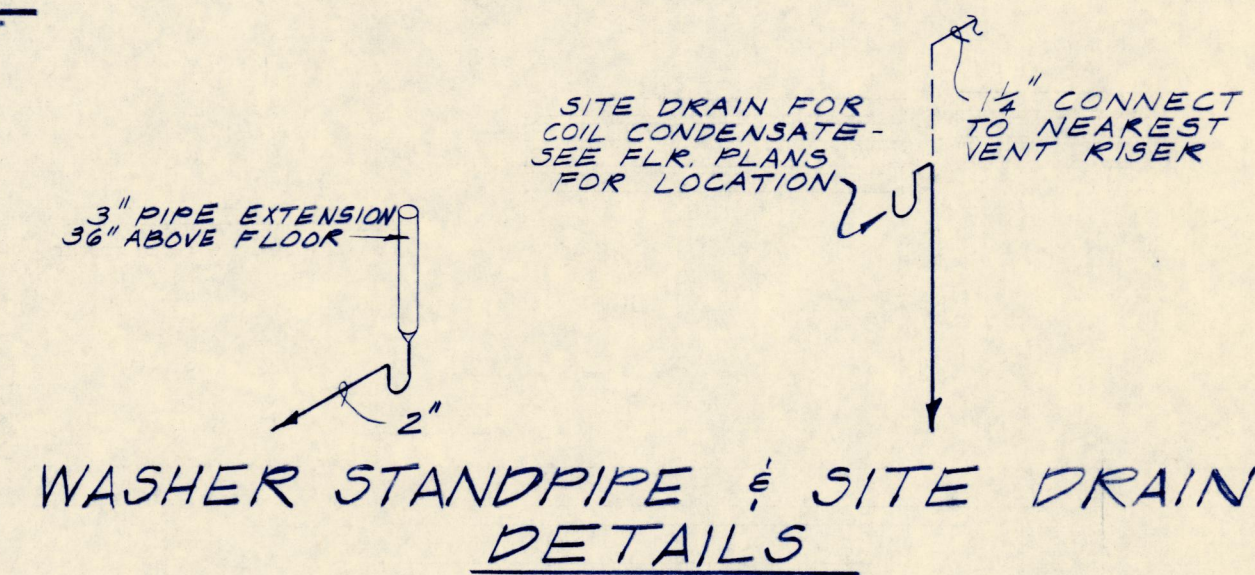


YARD HYDRANT DETAIL
NO SCALE

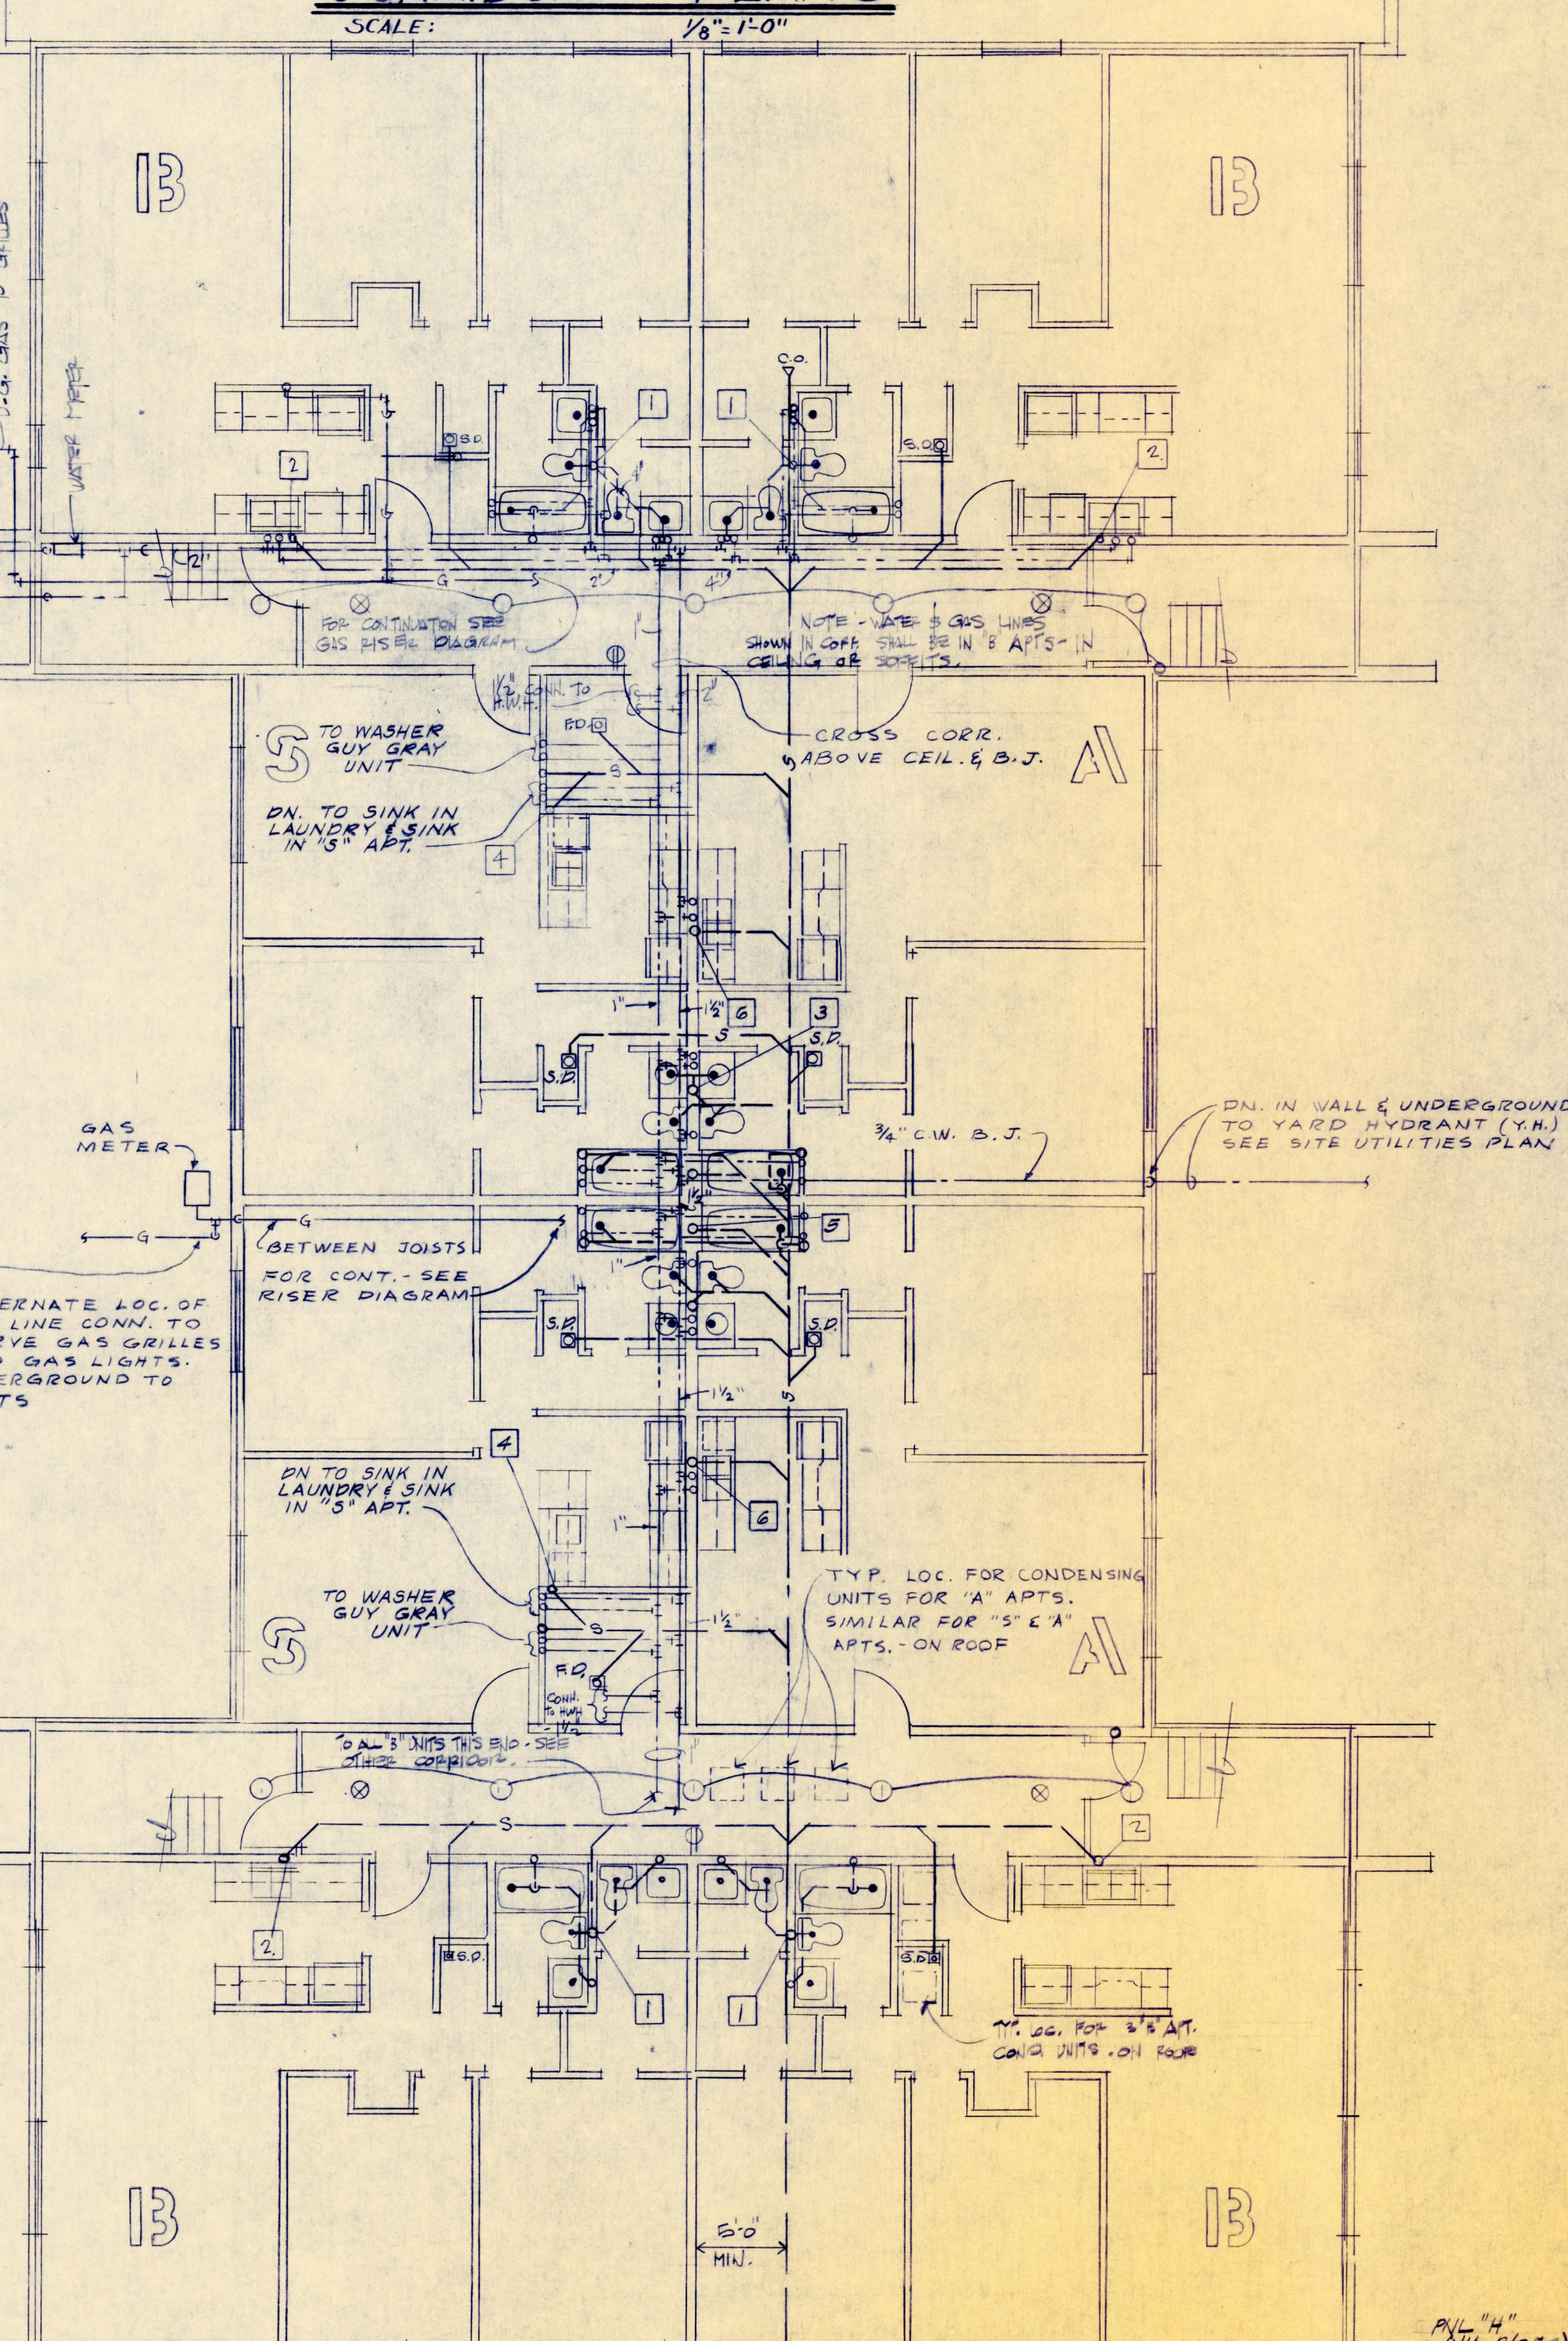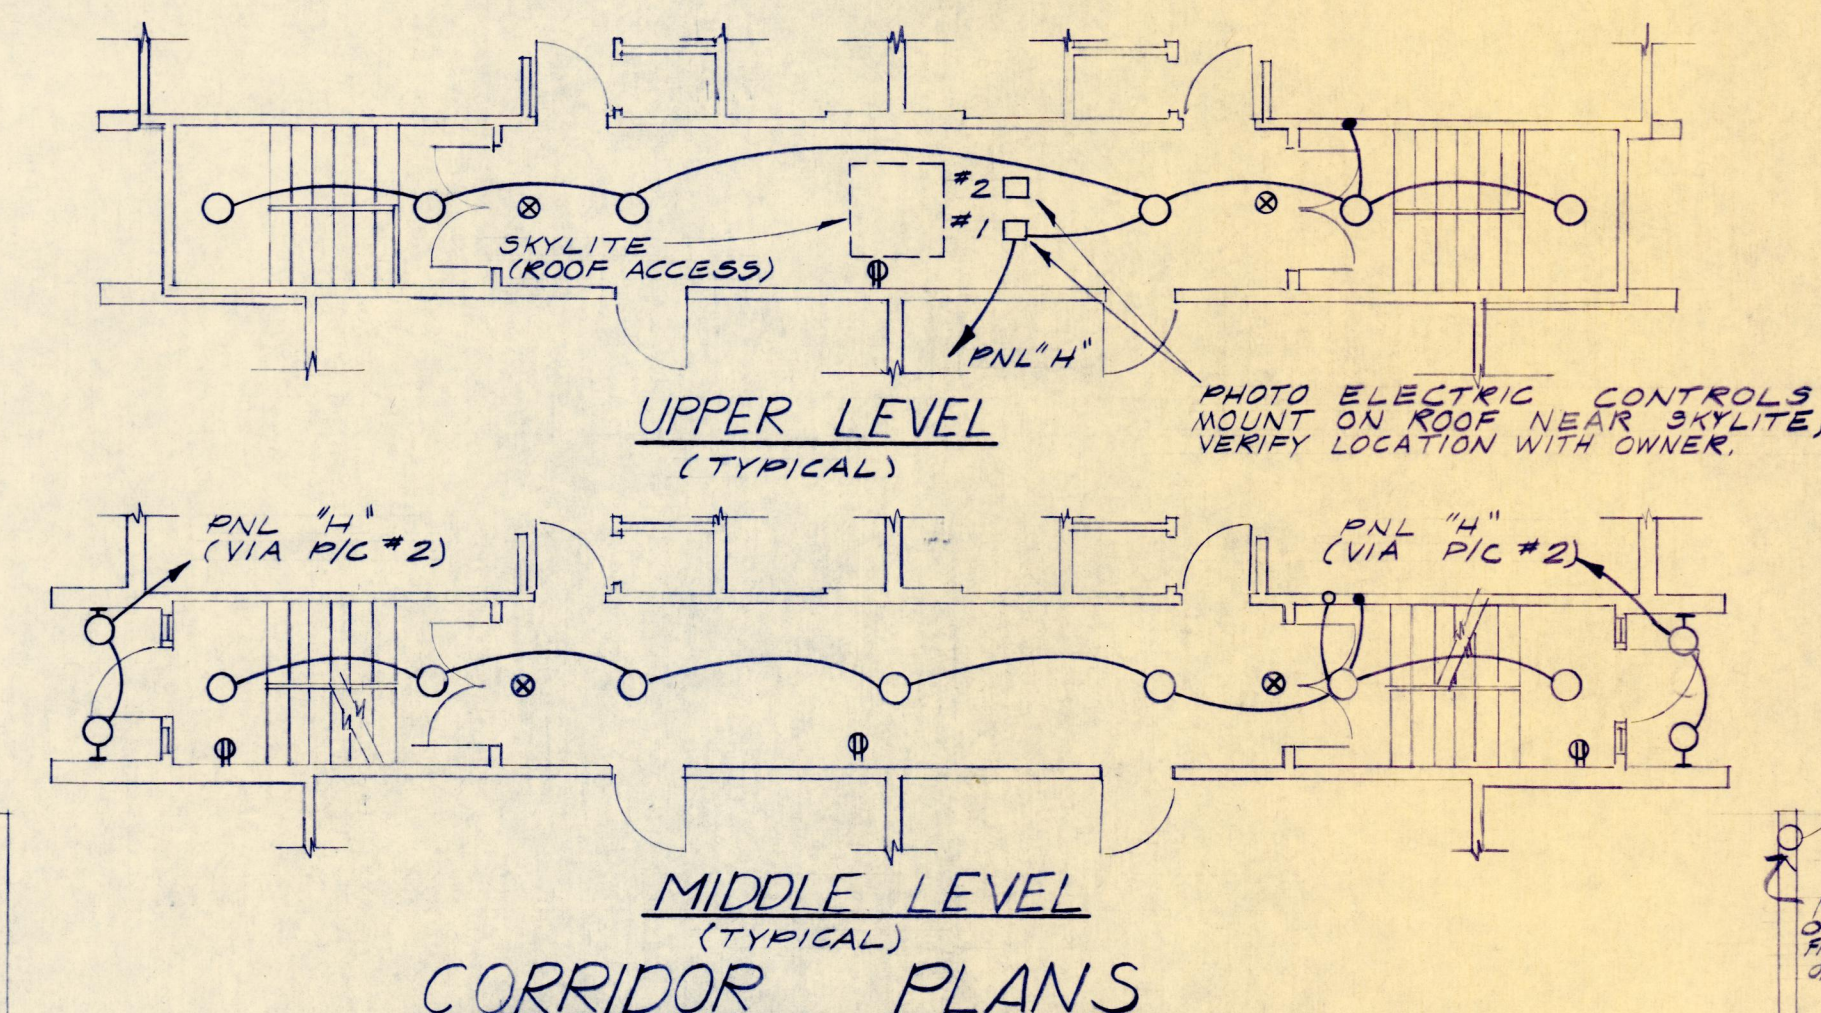


LOWER LEVEL PLAN
SCALE: 1/8" = 1'-0"

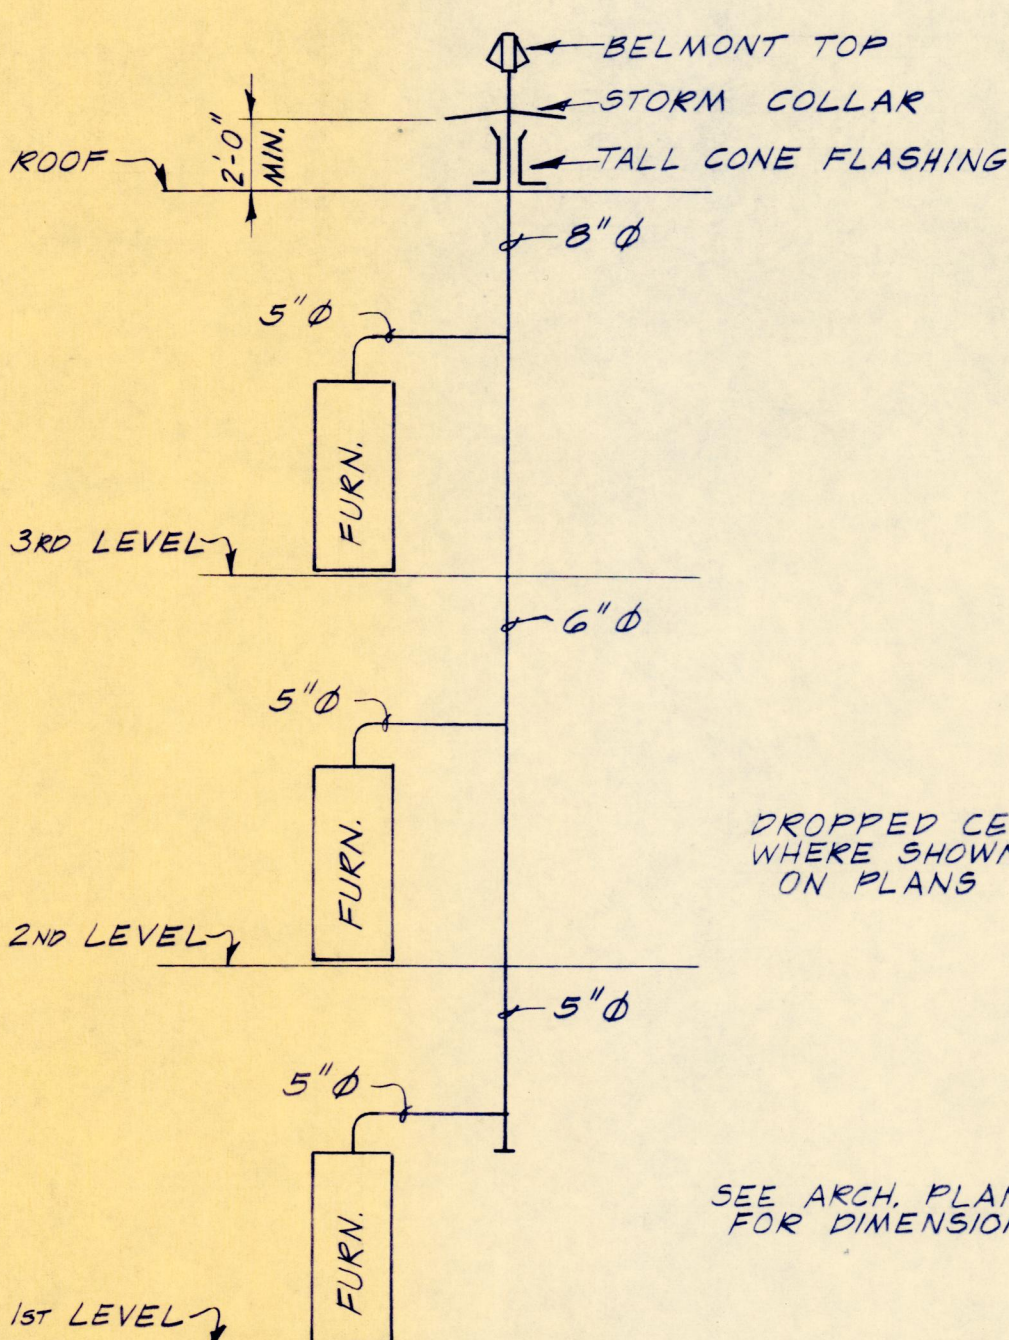


FLUE RISER DETAIL
NO SCALE

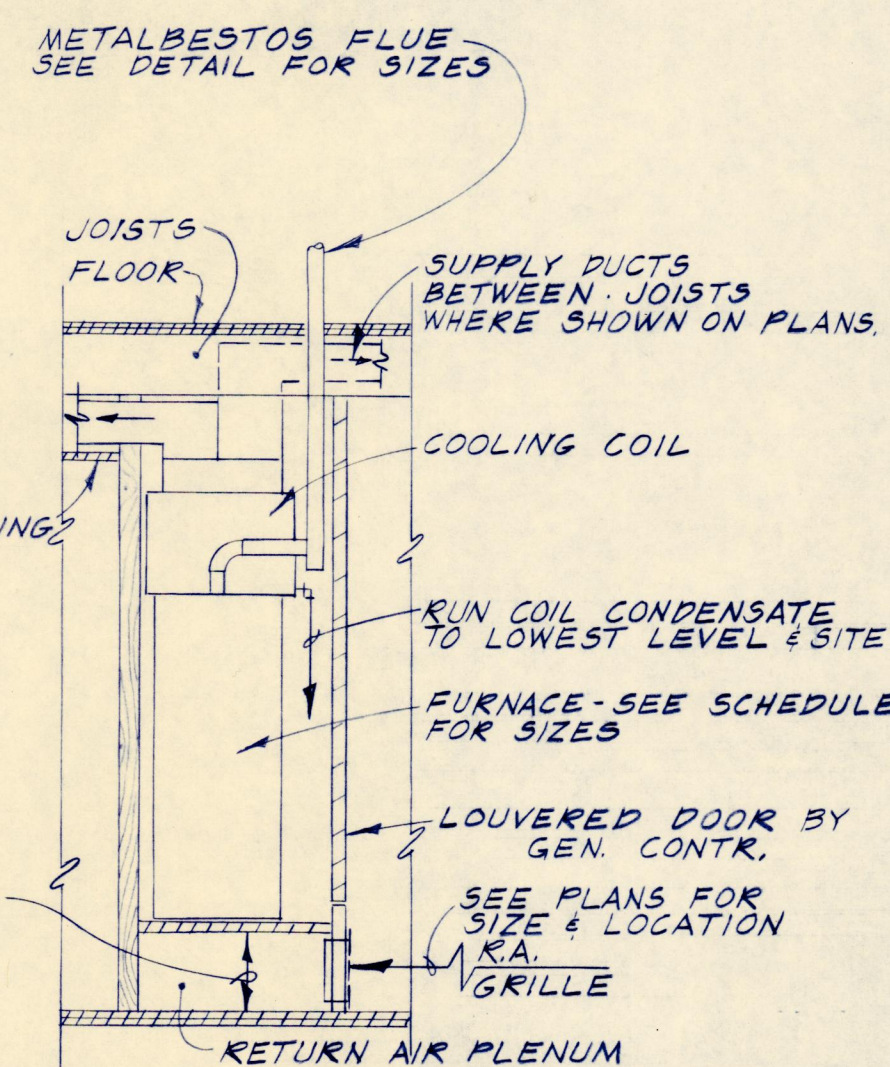


FURNACE ROOM DETAIL
NO SCALE

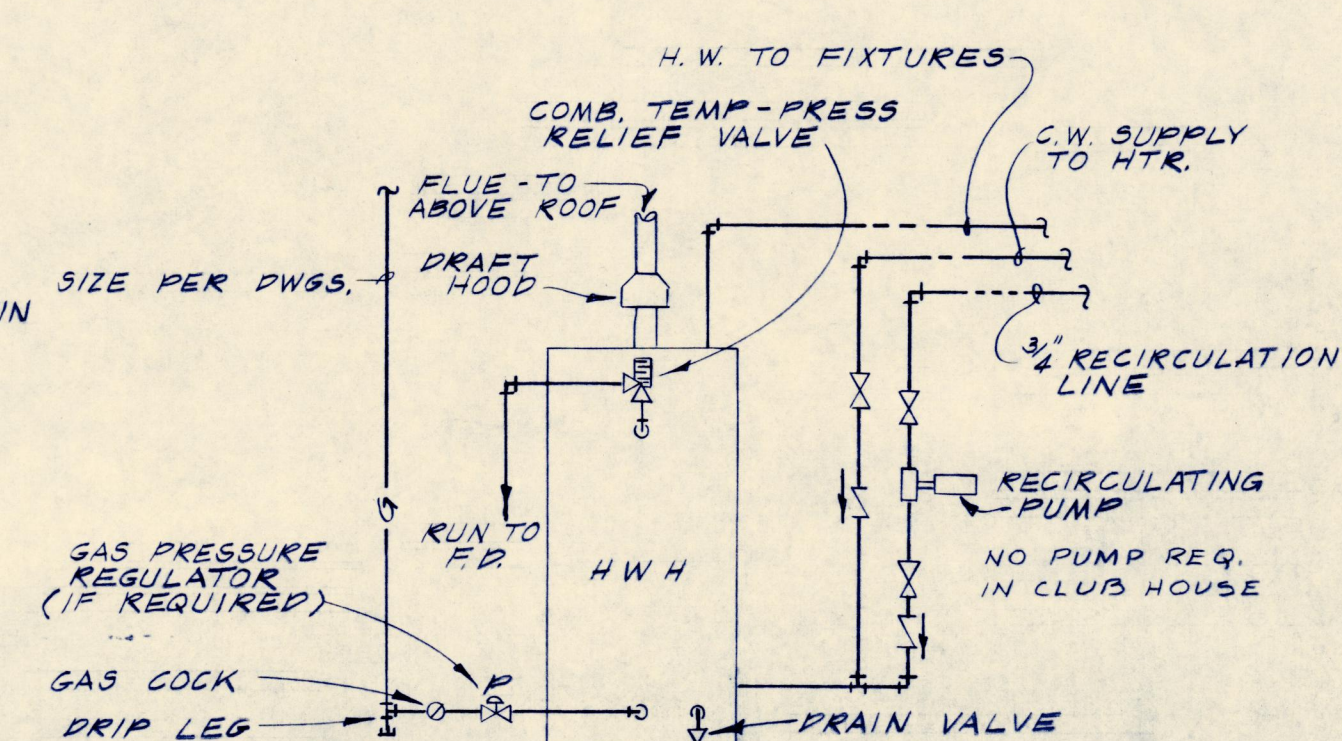


H.W.H. CONN. DETAIL
NO SCALE

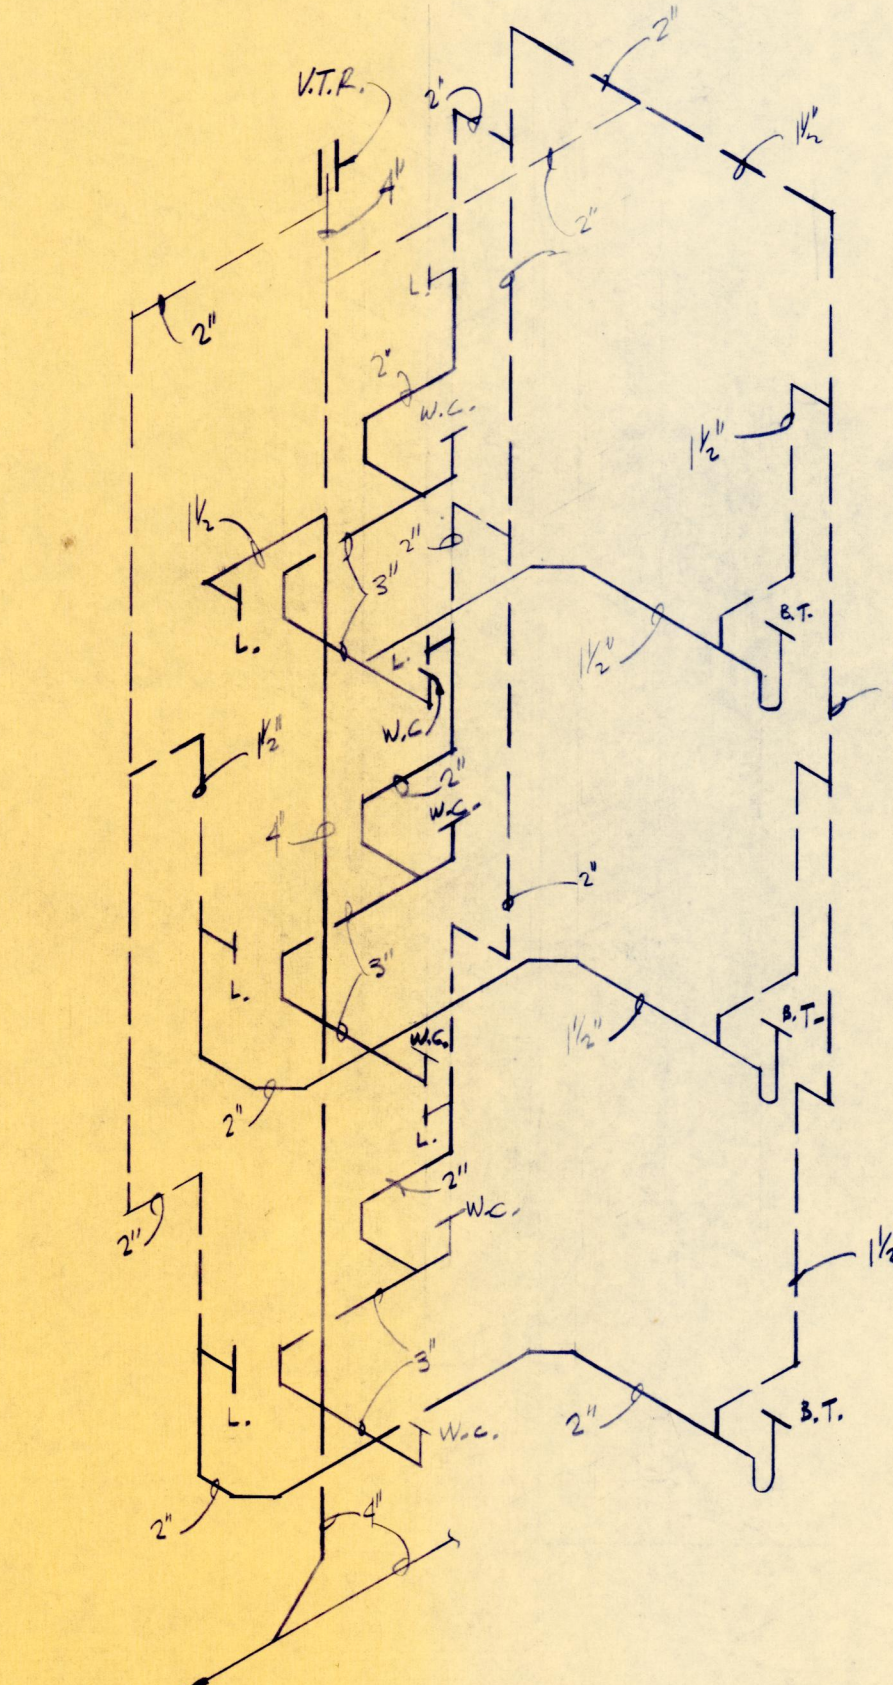


RISER #1 - TYP. FOR "B" APTS.

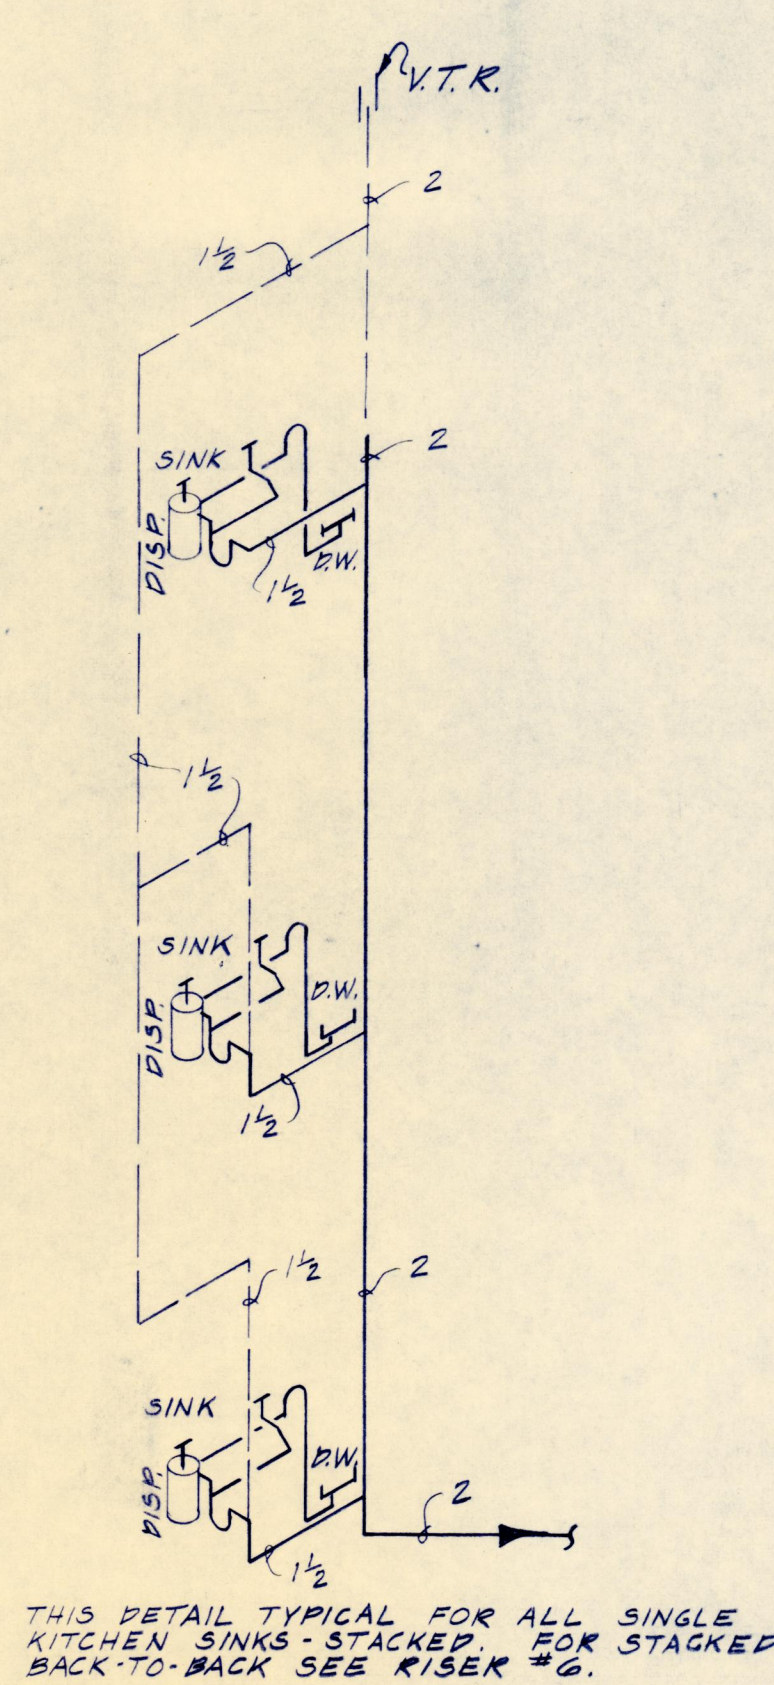


PLUMBING RISER #2
NO SCALE

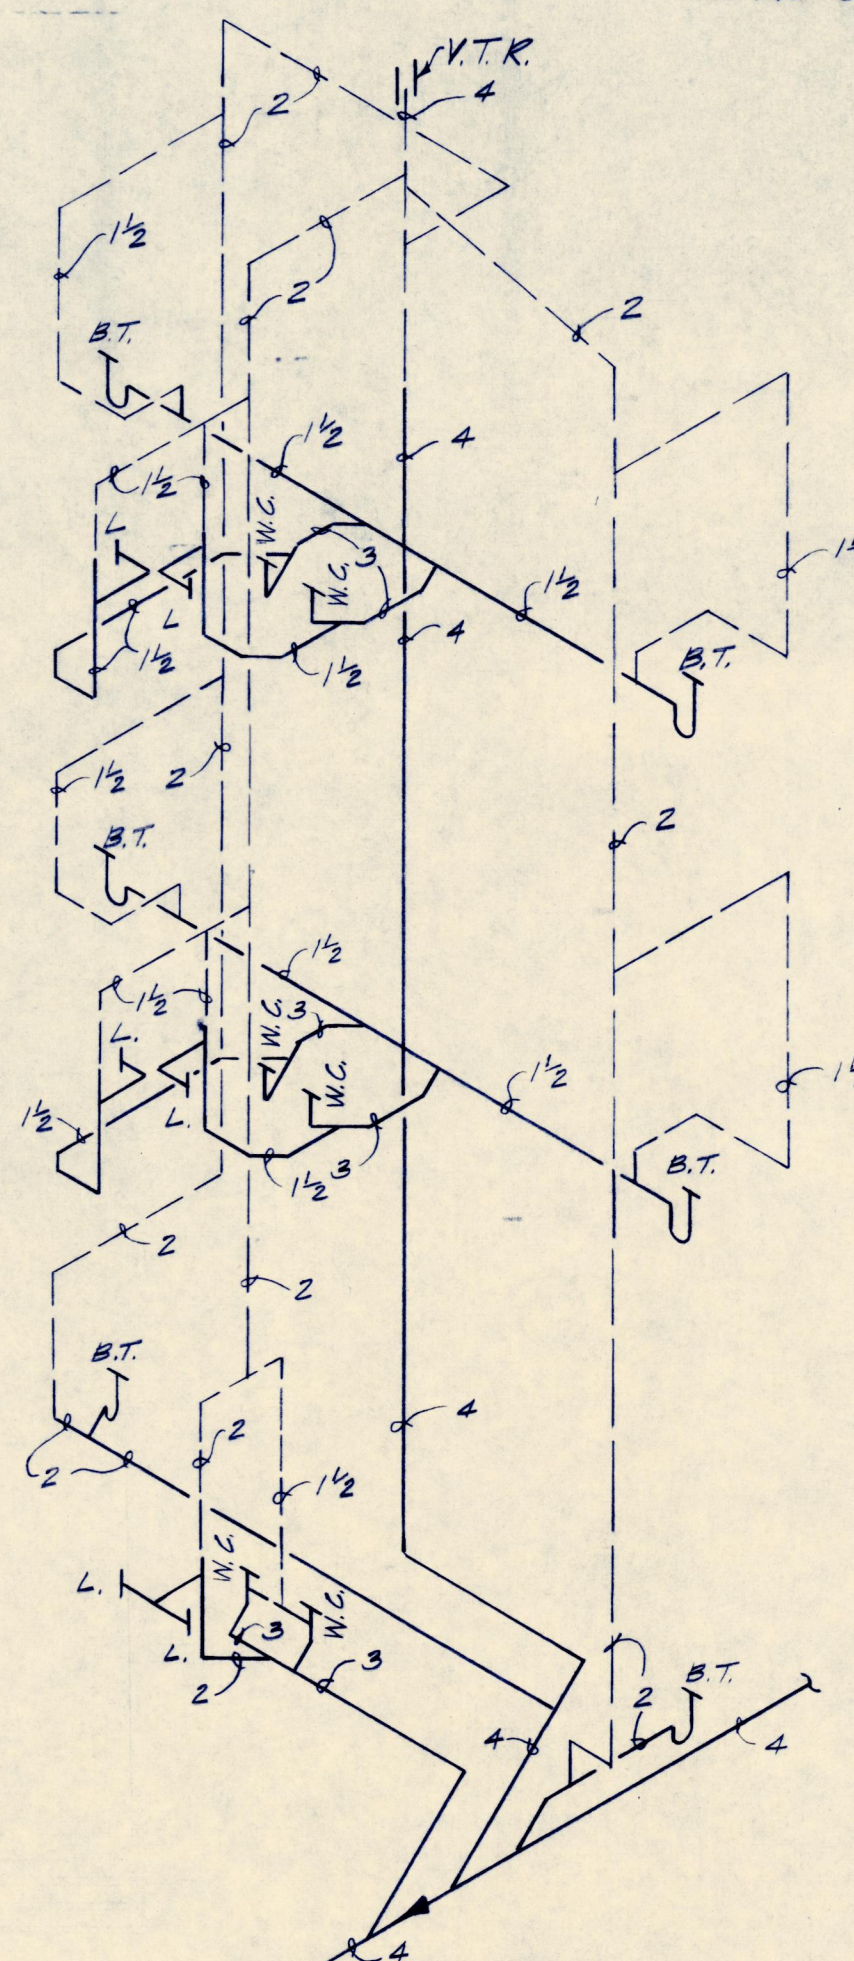

PLUMBING RISER #3 & #5
SCALE

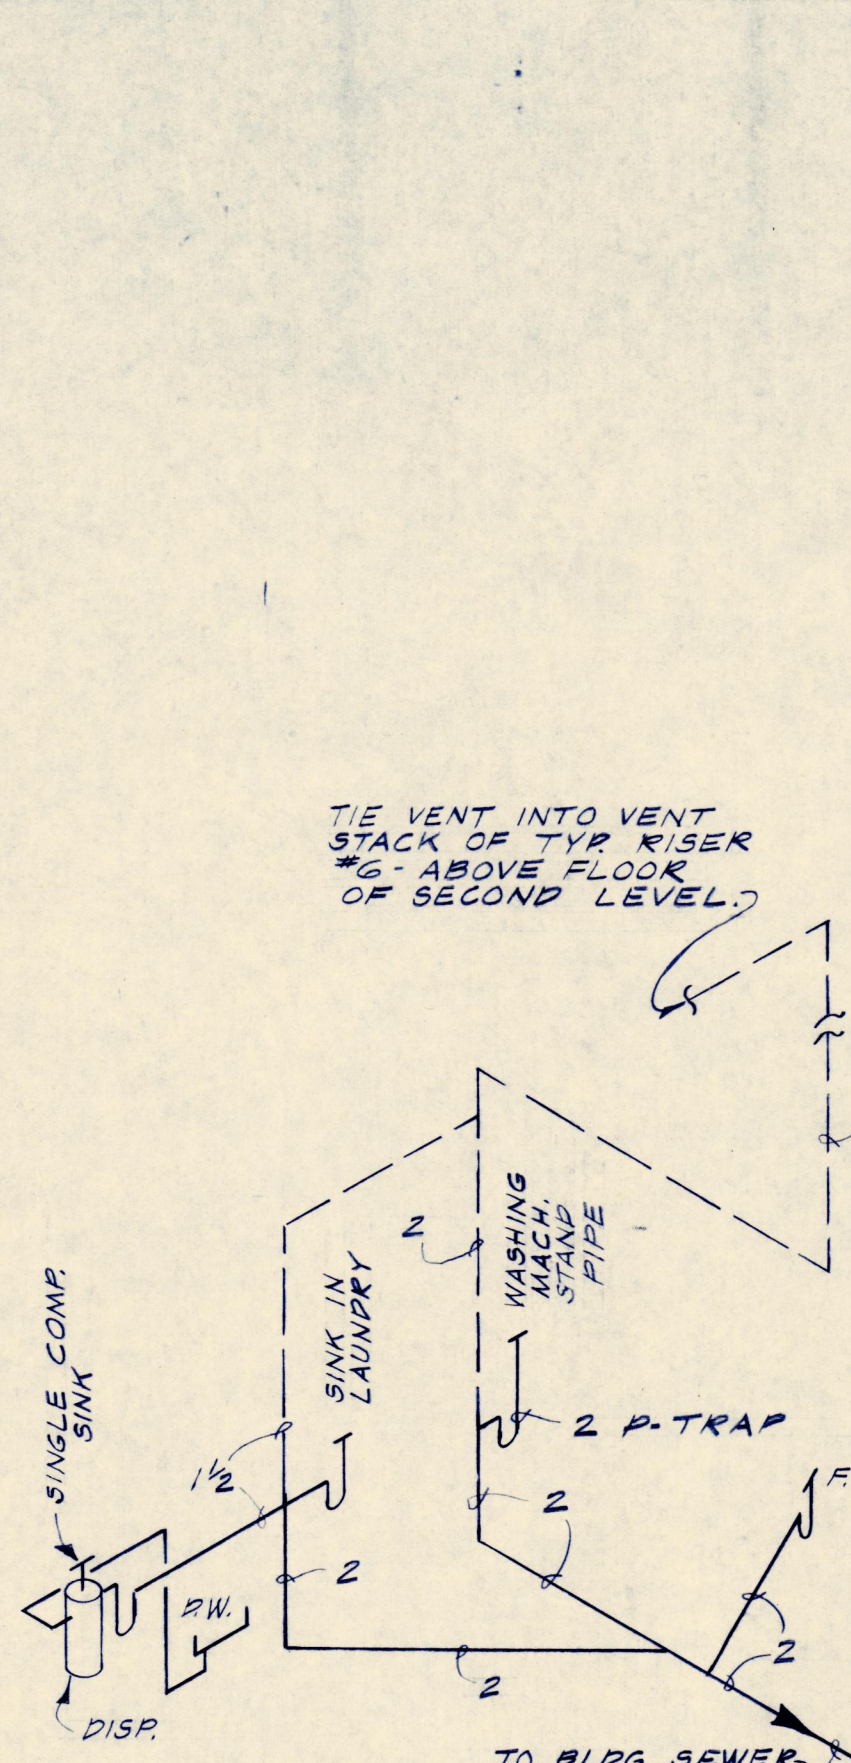

PLUMBING RISER #4

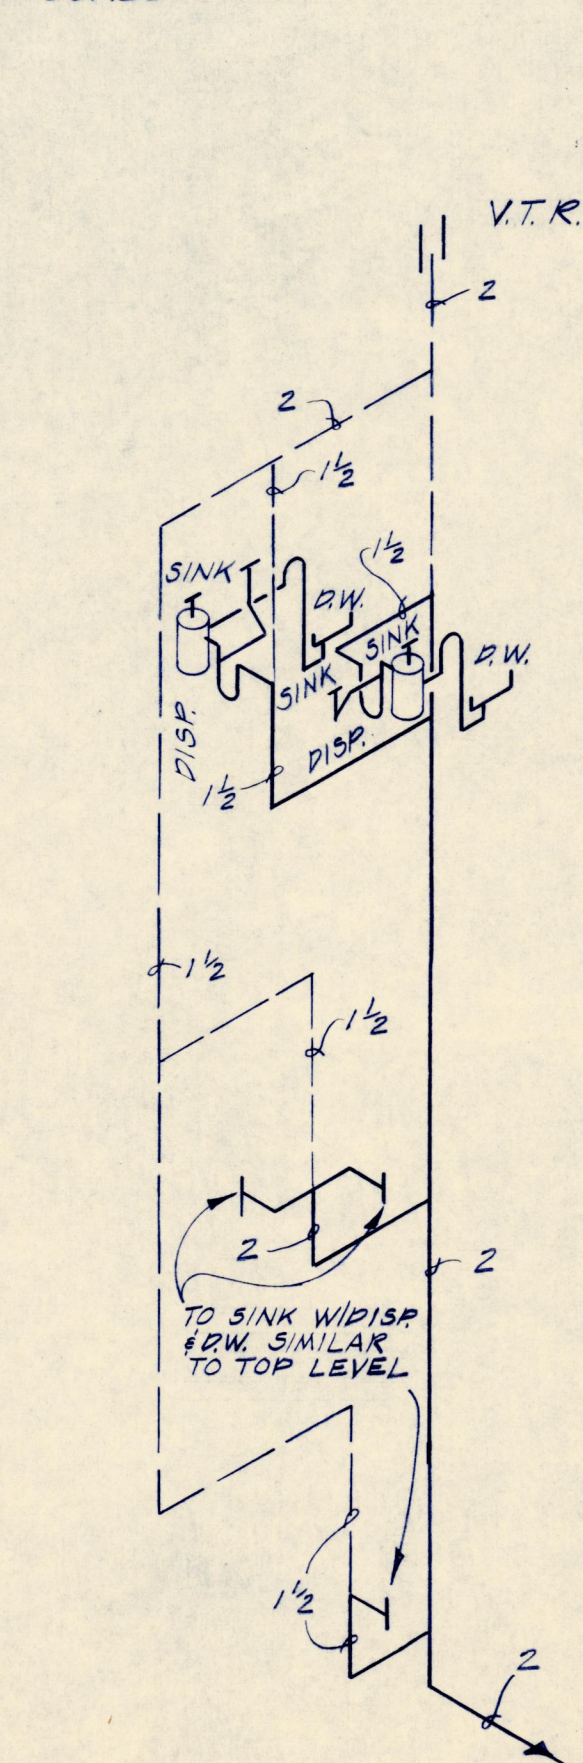

PLUMBING RISER #6

JOB NUMBER	312A
DATE	6-7-71
JOB CAPTAIN	FUSTON
DRAWN BY	E.A.
CHECKED BY	FUSTON
REVISIONS	10-7-71

(402) 397-7557

OMAHA, NEBRASKA 68106

6969 GROVER STREET

r. bruce widstrom associates · architects

SHEET NUMBER
15
TOTAL SHEETS

2007.33.2326Q

ENGINEERING ASSOCIATES, INC.
consulting engineers