



- NOTES:
1. CONNECT H&C WATER, VENT & DRAIN LINES TO NEW LAV & TOILET WHERE OLD FIXTURES REMOVED IN EMPLOYEE TOILETS.
 2. NOTE NEW JAN SINK TO BE CONNECTED TO H&C WATER NEW 3" CI DRAIN INTO EXISTING STACK & NEW 2" VENT THRU ROOF.
 3. NEW STAINLESS STEEL SINKS ON SECOND & THIRD FLOOR TO BE CONNECTED TO H&C WATER, VENT & EXISTING DRAIN LINES.
 4. REMOVE EXISTING PLUMBING FIXTURES FROM 3 TOILETS ON NORTH EAST CORNER OF BLDG. INSTALL NEW FIXTURES AS SHOWN WITH NEW 2" GALV STEEL SOIL LINE & 1 1/2" GALV HW. LINE.
 5. EXISTING DRINKING FOUNTAIN TO REMAIN.
 6. CONNECT EXISTING STANDPIPES TO G-NEW FIRE NOSE CABINETS.
 7. CHASE HOT & COLD WATER LINES WITH 1" FIBERGLASS INSULATION IN OUTSIDE WALL FOR 2ND & 3RD FLOOR SHOWERS.

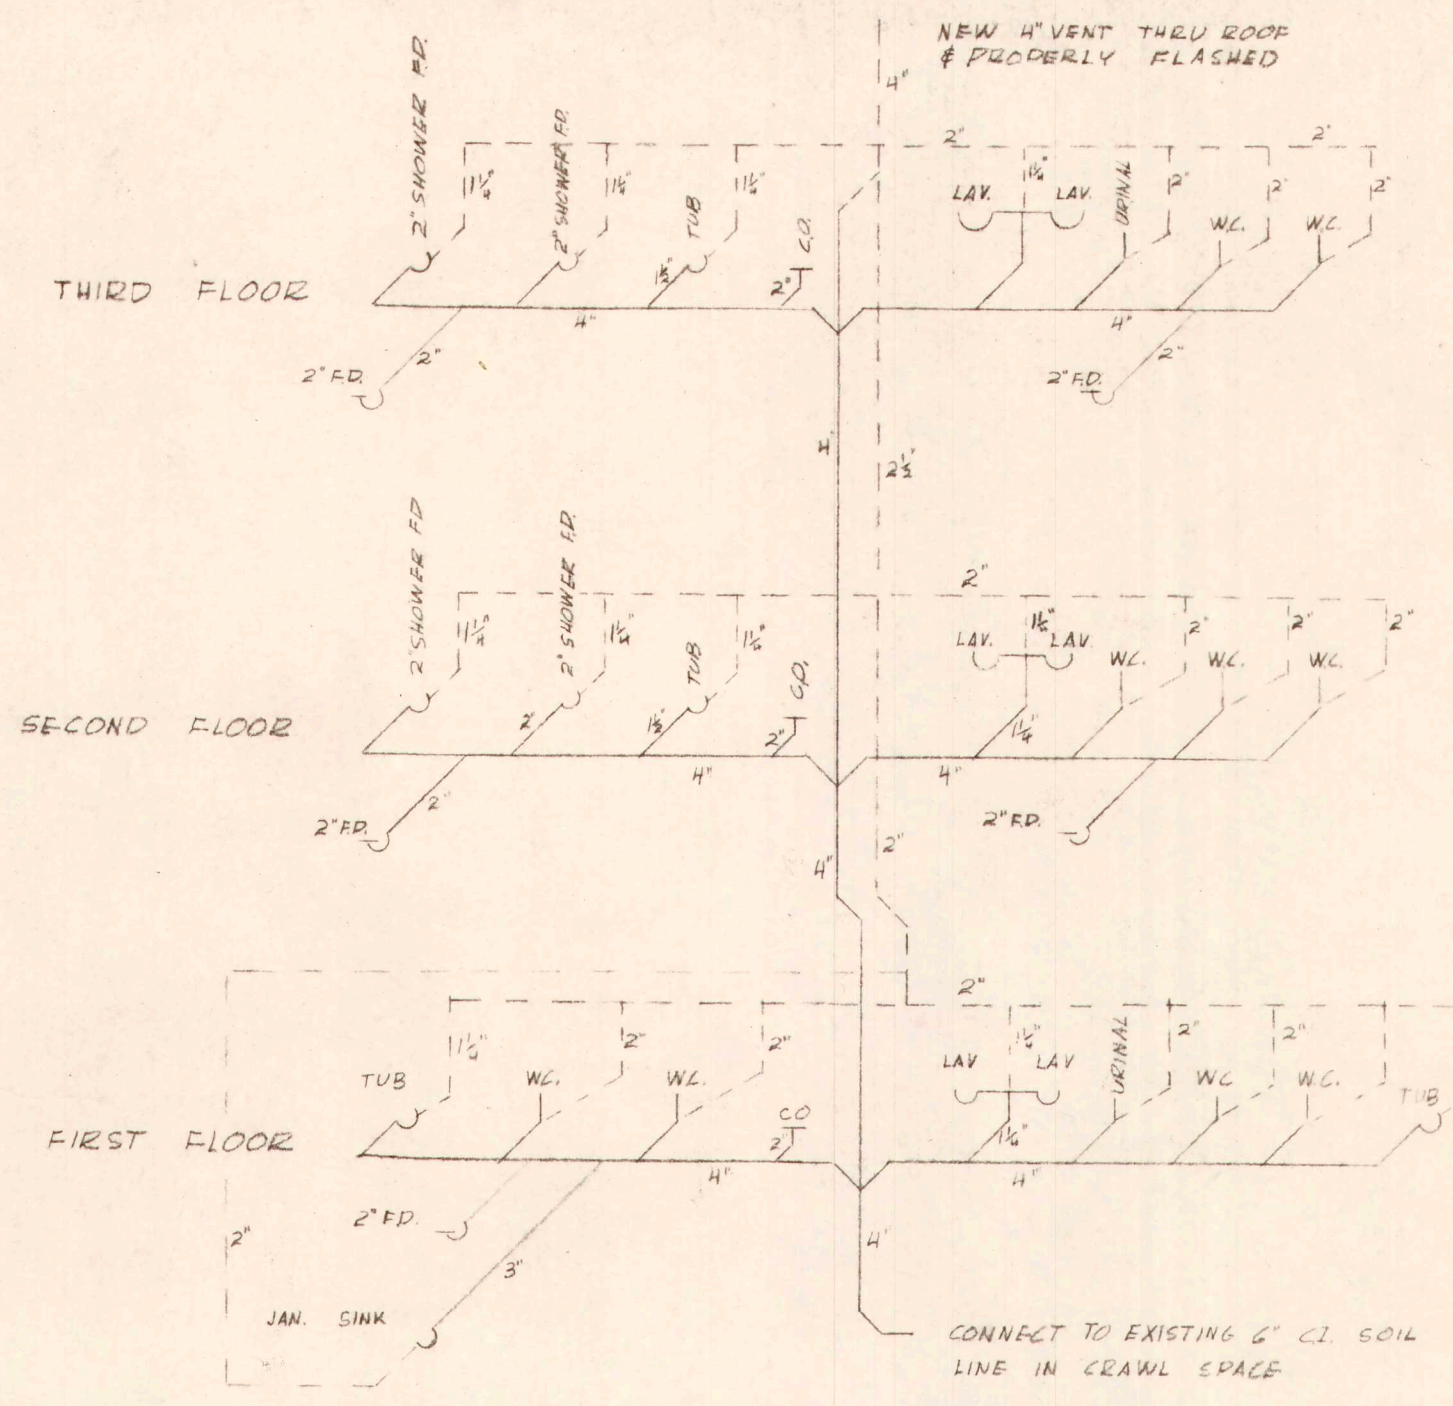

PLUMBING RISER DIAGRAM
NOT TO SCALE

FIXTURE SCHEDULE				
MARK	LOCATION	MFG	CAT. NO.	LAMPS
A	CORRIDORS	SUTH	GE 4985	2-40W
B	TOILETS	MARKSTONE	W-90-76	100W
C	STAIRS	ART METAL	2879 SL	2-60W
D	JAN. CL.	PORCELAIN		100W
E	INTERVIEW & REG ROOMS	SUTH	GE 6305	2-40W
F	REG. AREA, OFF. & KIT	SUTH	GE 6306	3-40W
G	NURSE STATION	LIGHTOLIFE	10245	1-30W
H	DEFENSEN ROOM	SUTH	B-142	100W
I	EXTERIOR LIGHTS	PRESCOTT	WB-24	100W
	EXIT LIGHTS		TO MATCH EXISTING	

10 #10S / SIDE OF MAIN

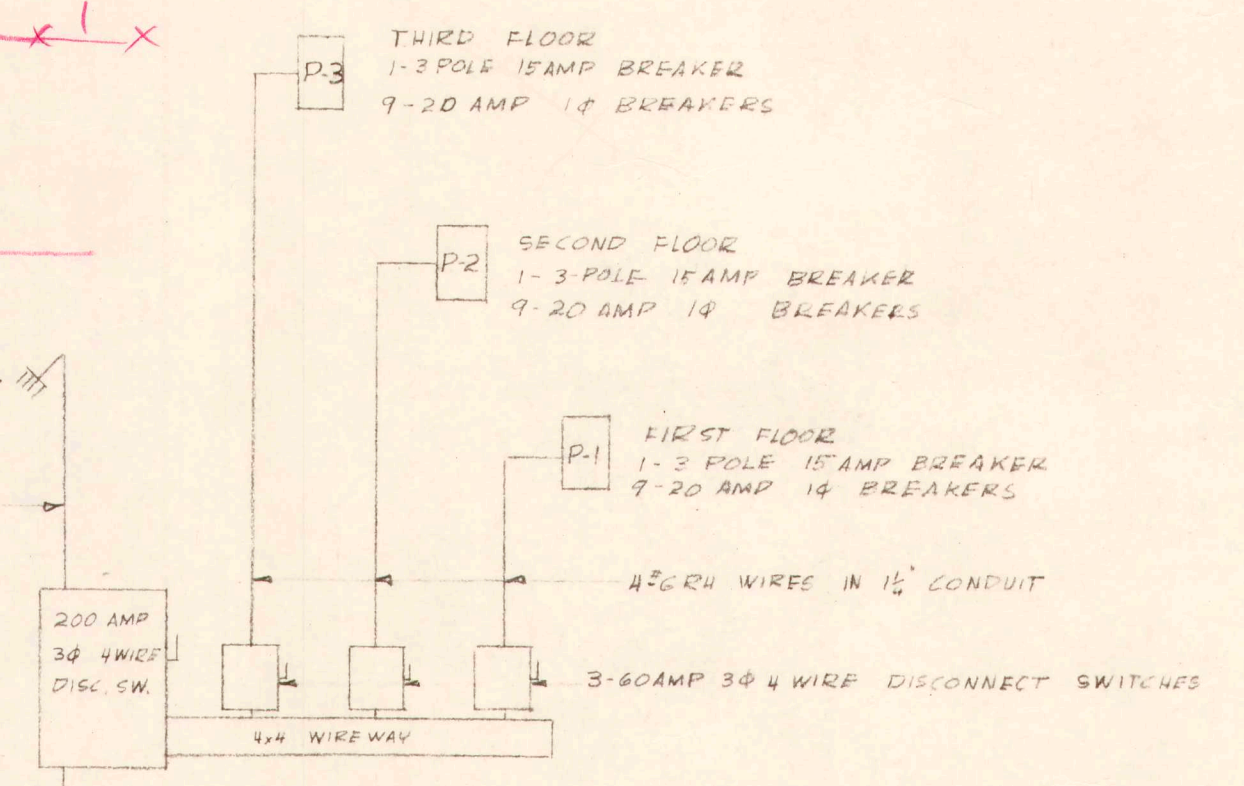

ELECTRICAL RISER DIAGRAM
NO SCALE

- NOTES:
1. RELOCATE CONDUIT & WIRING WHERE CUT BY DUCTWORK OR REMOVED WALLS.
 2. RELOCATE EXISTING FIXTURES IN UNIT ROOMS TO CLEAR UNIT & DUCTWORK.
 3. "E" FIXTURES TO BE MOUNTED ON EXISTING OUTLETS WHERE SHOWN AND CONTROLLED FROM EXISTING SWITCHES.
 4. EXISTING EMERGENCY LIGHTING TO REMAIN.

THIRD FLOOR PLAN
SCALE 1/8" = 1'-0"

SECOND FLOOR PLAN
SCALE 1/8" = 1'-0"

FIRST FLOOR PLAN
SCALE 1/8" = 1'-0"

ELECTRICAL & PLUMBING ALTERATIONS OF THE O.T. BUILDING FOR A CHILD TREATMENT CENTER MISSOURI STATE HOSPITAL N22 ST. JOSEPH, MISSOURI			
DATE MARCH 1, 1962	JOHN M. DALTON BRUNNER & BRUNNER ARCHITECTS & ENGINEERS St. Joseph, Missouri	GOVERNOR ARCHITECTS & ENGINEERS Missouri	SHEET
Approved <i>William A. Brunner</i> DIRECTOR	Approved <i>John S. Paulsen Jr.</i> CHIEF		
DEPT. OF HEALTH & WELFARE		PLANNING & CONSTRUCTION SECTION	

