
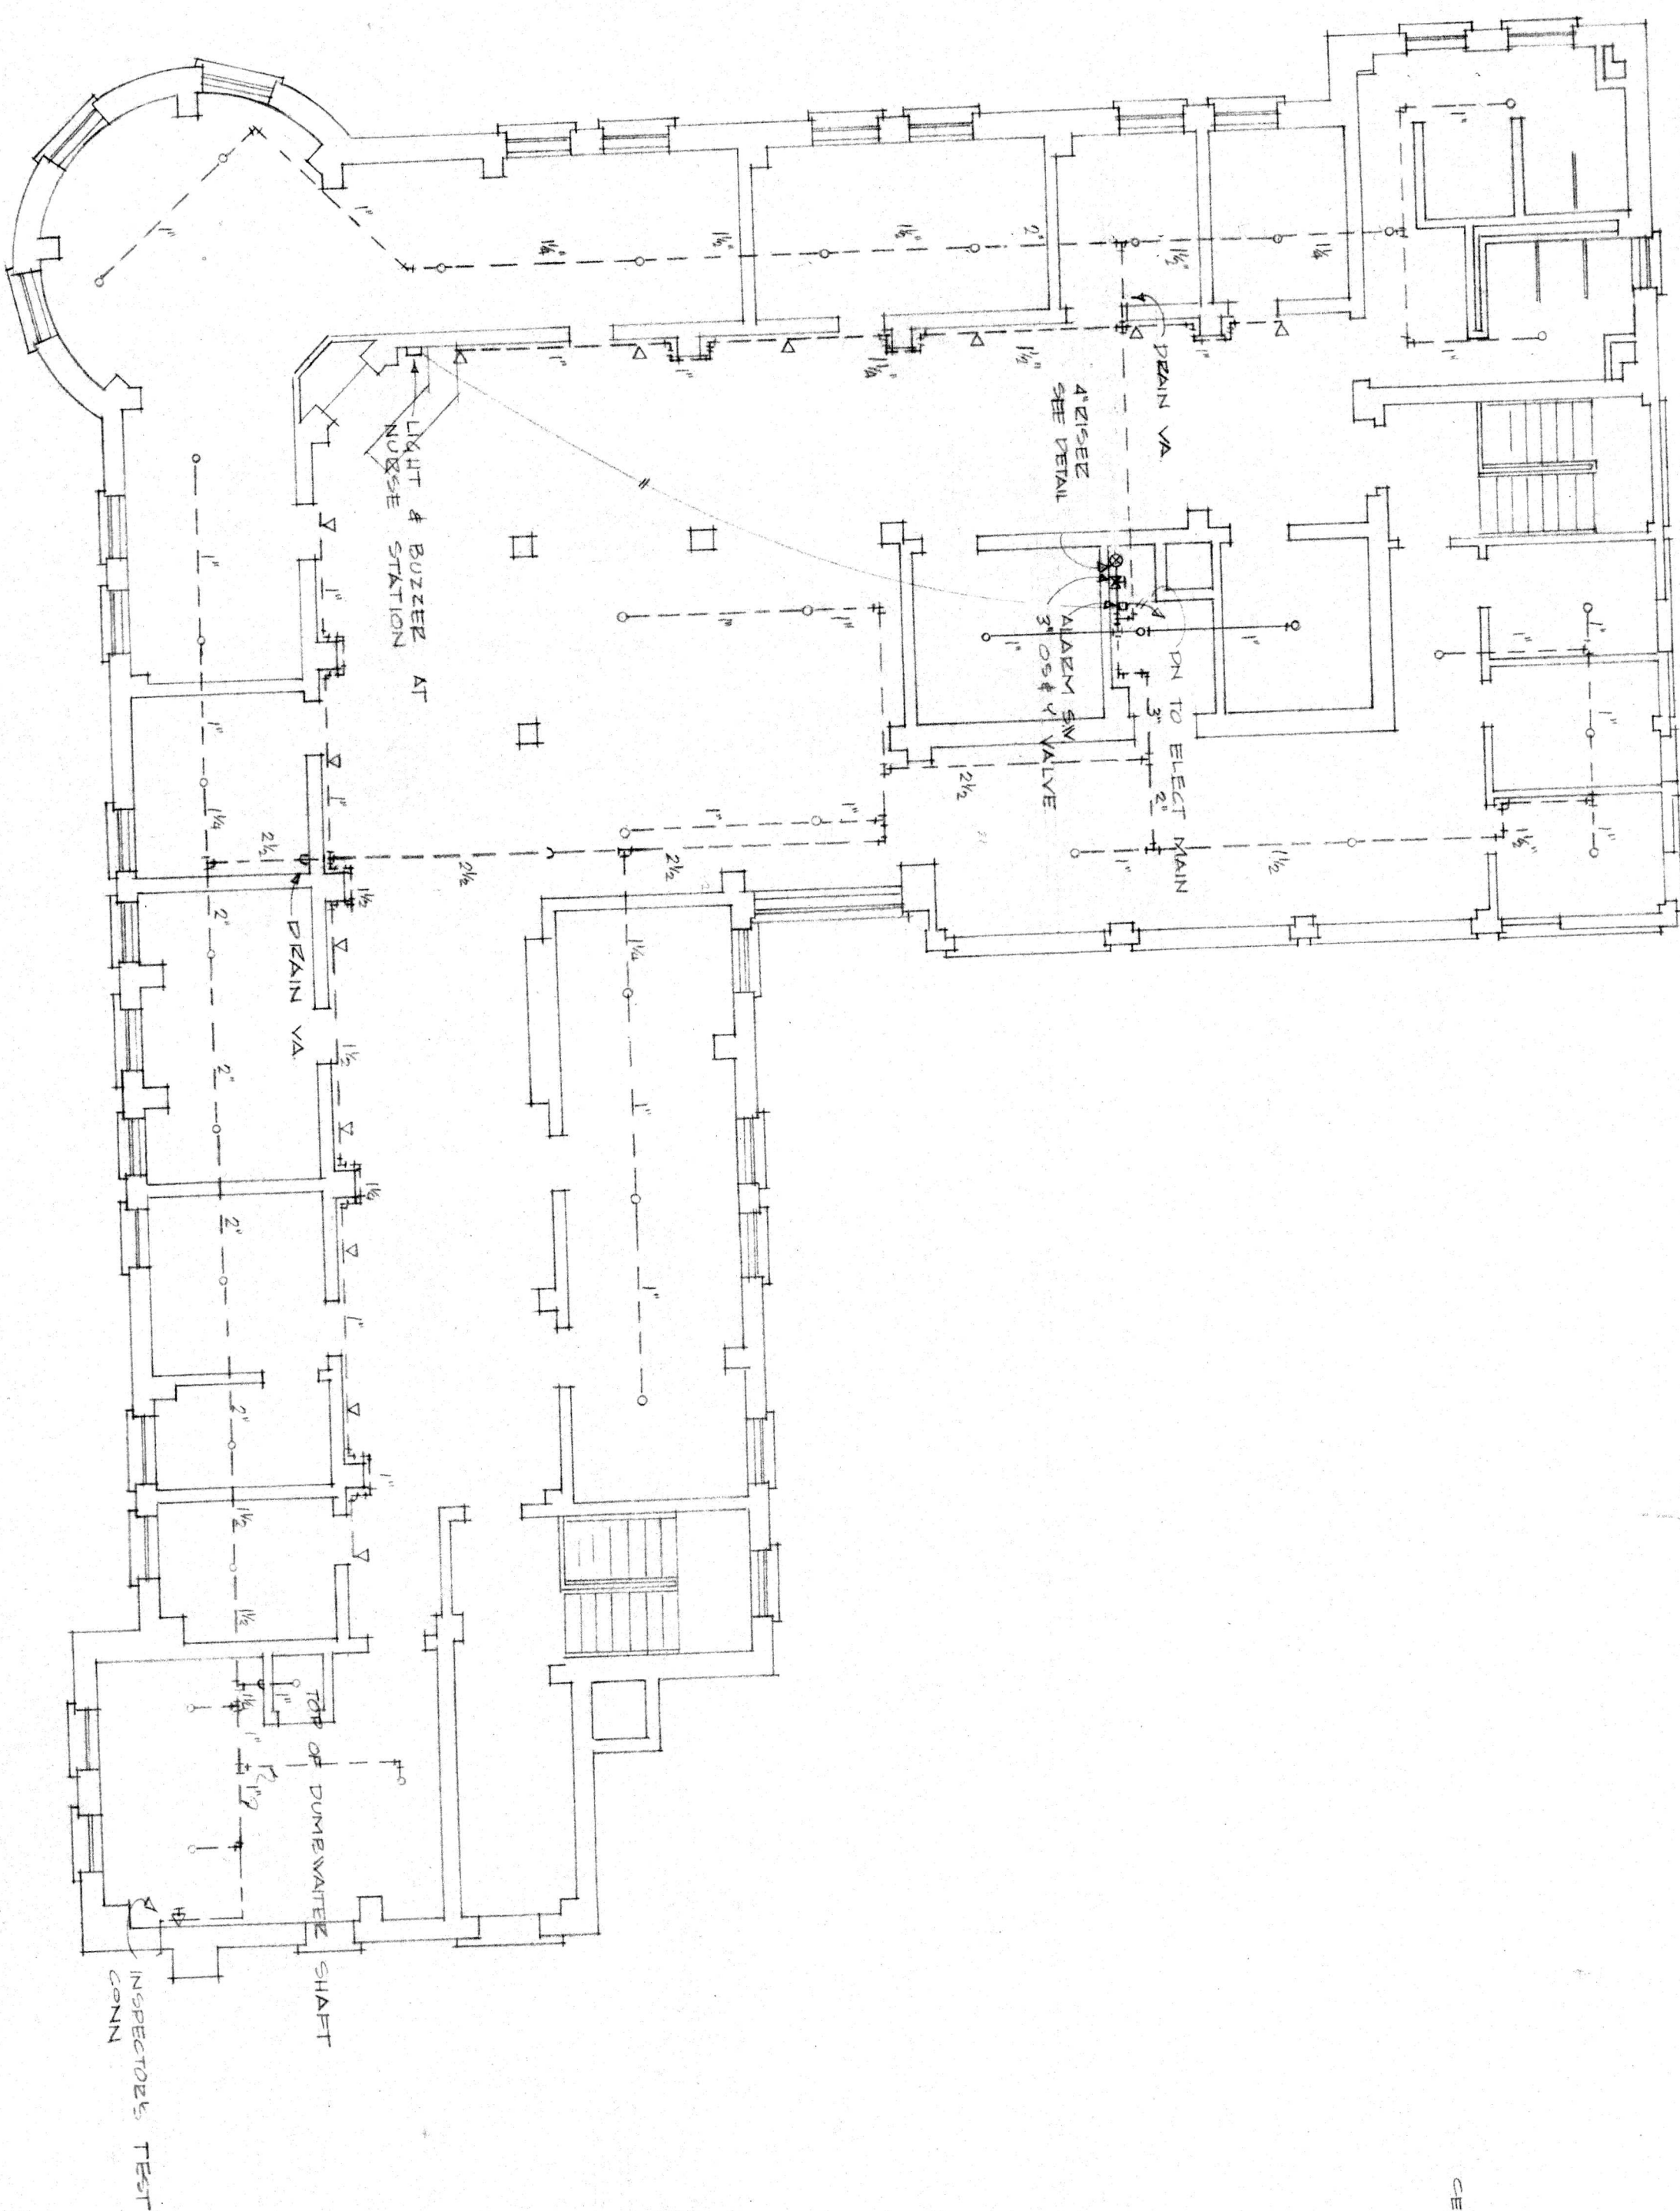



THIRD FLOOR PLAN

SCALE 1/8"=1'-0"

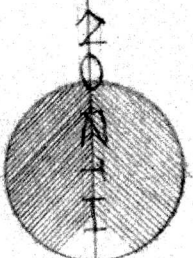


FIRST FLOOR PLAN

SCALE 1/8"=1'-0"

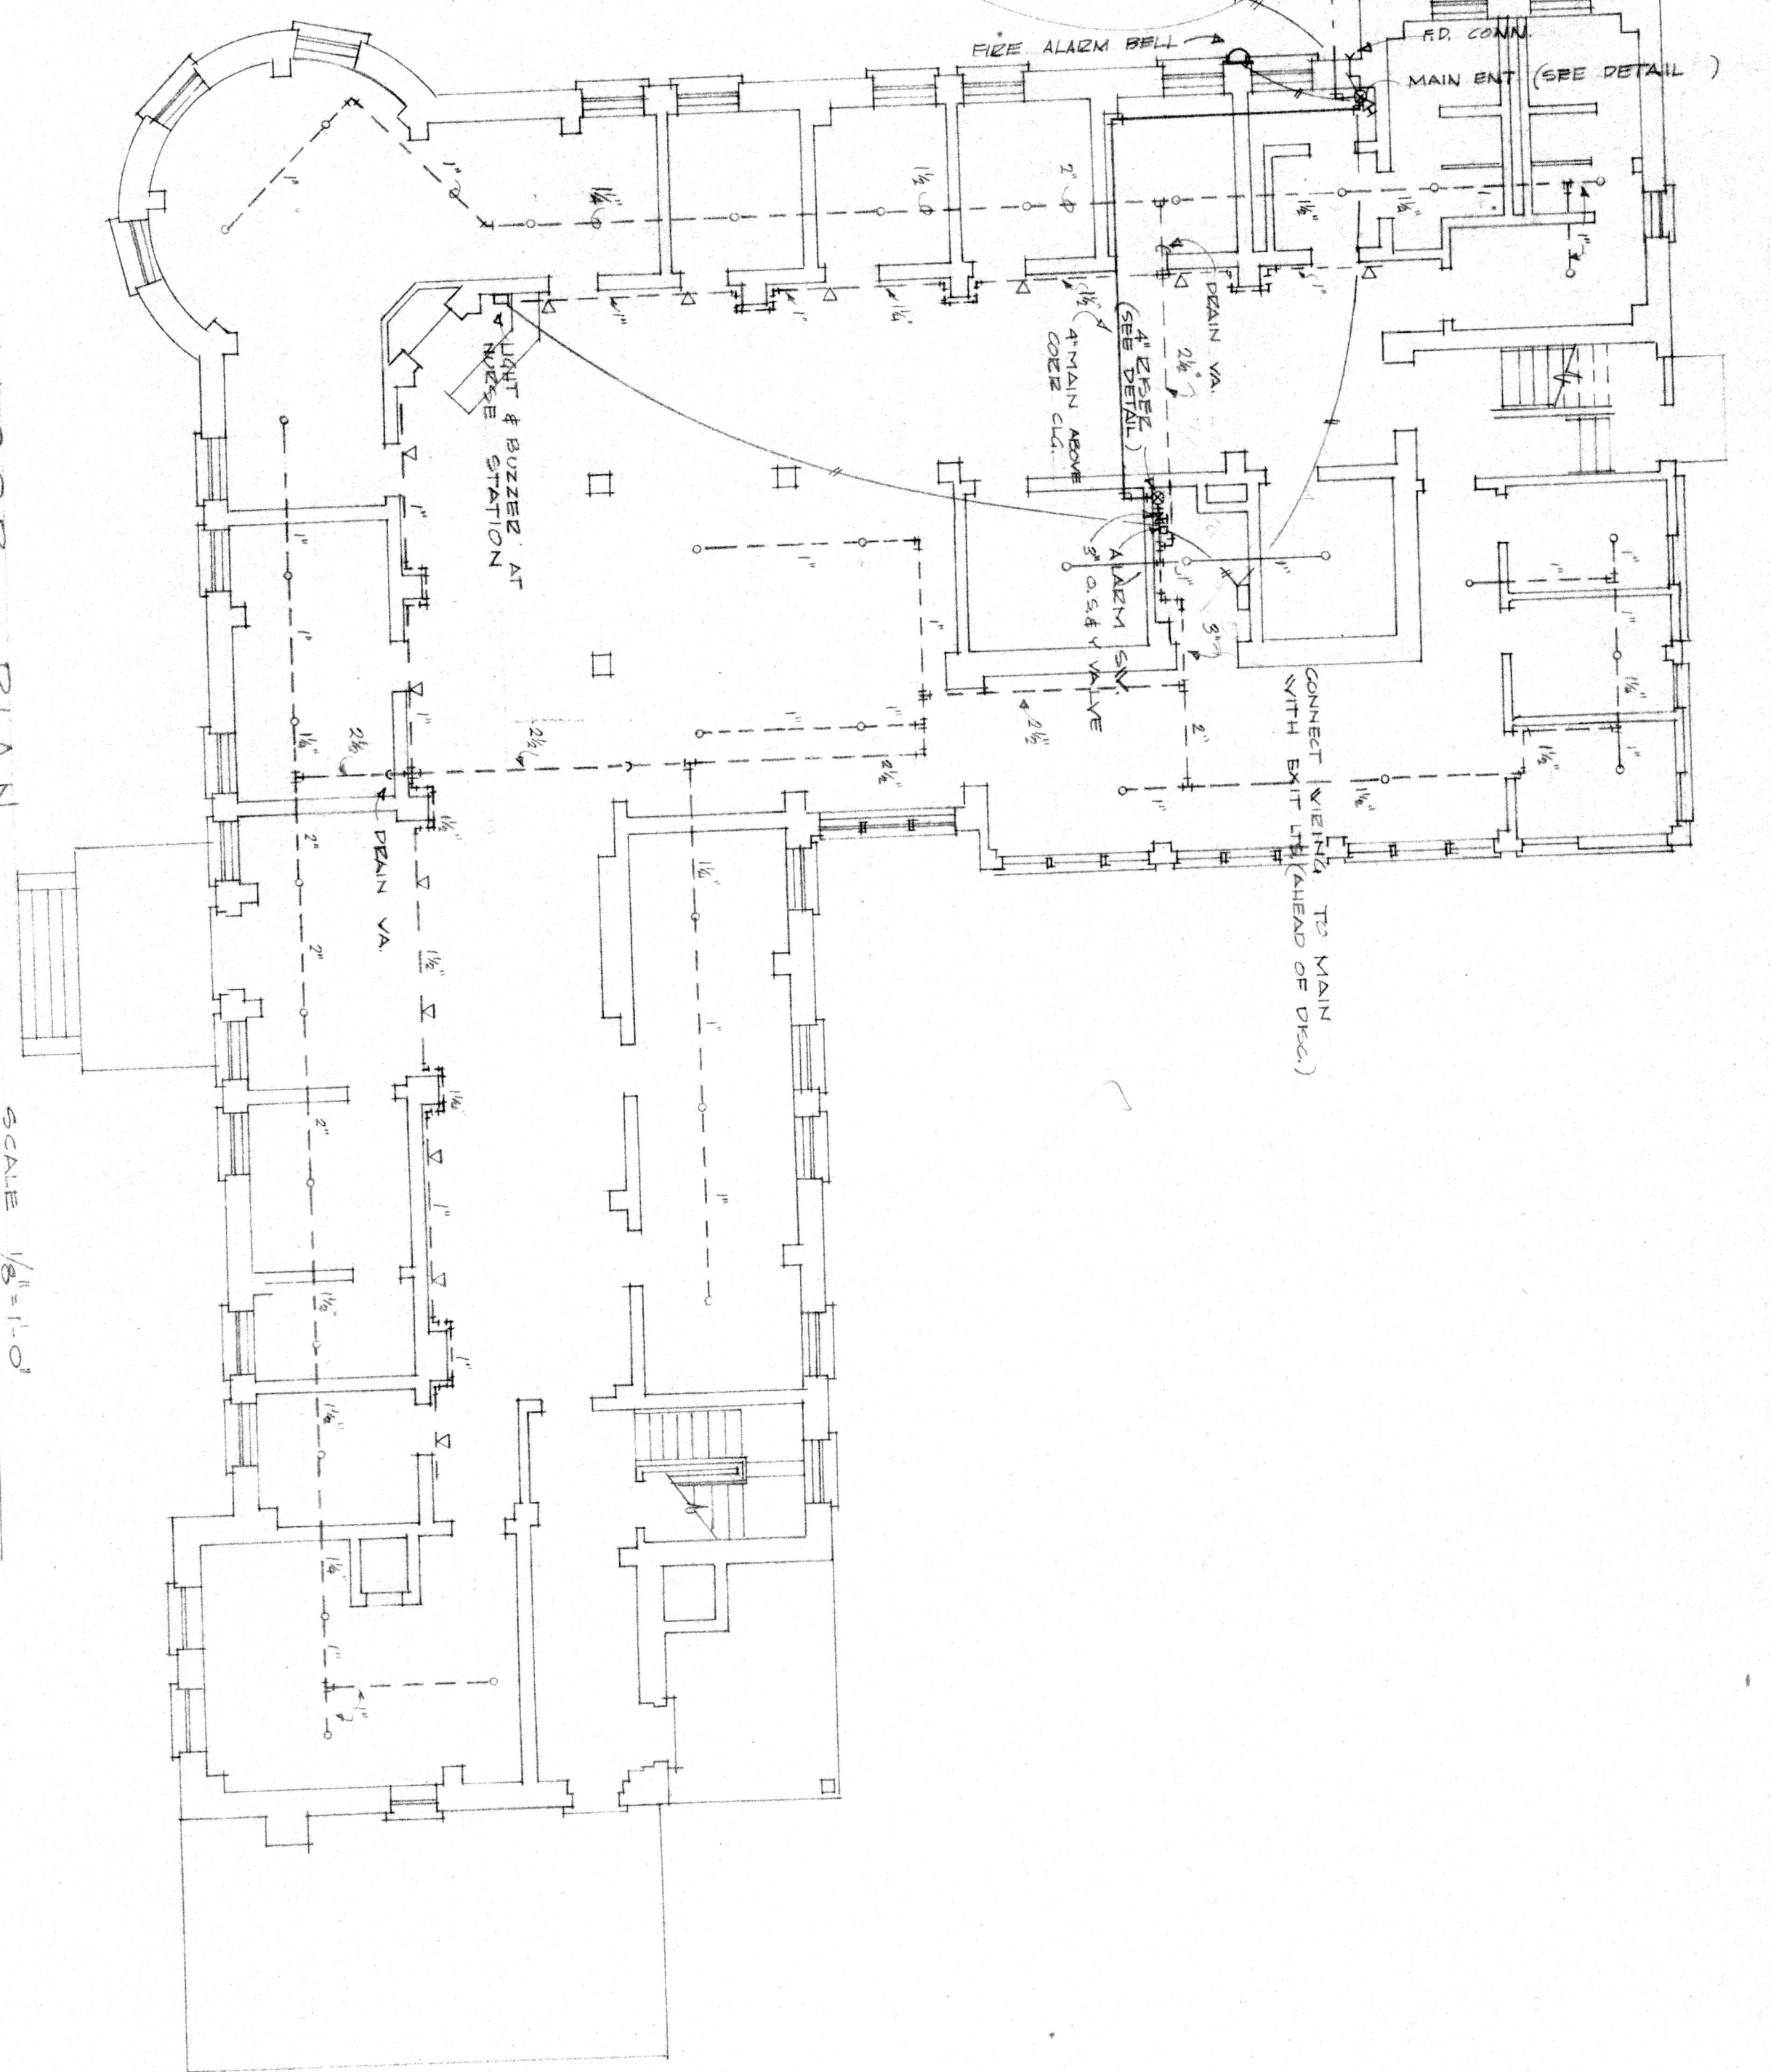


SPRINKLER SYSTEM ELEVATION DIAGRAM

NO SCALE

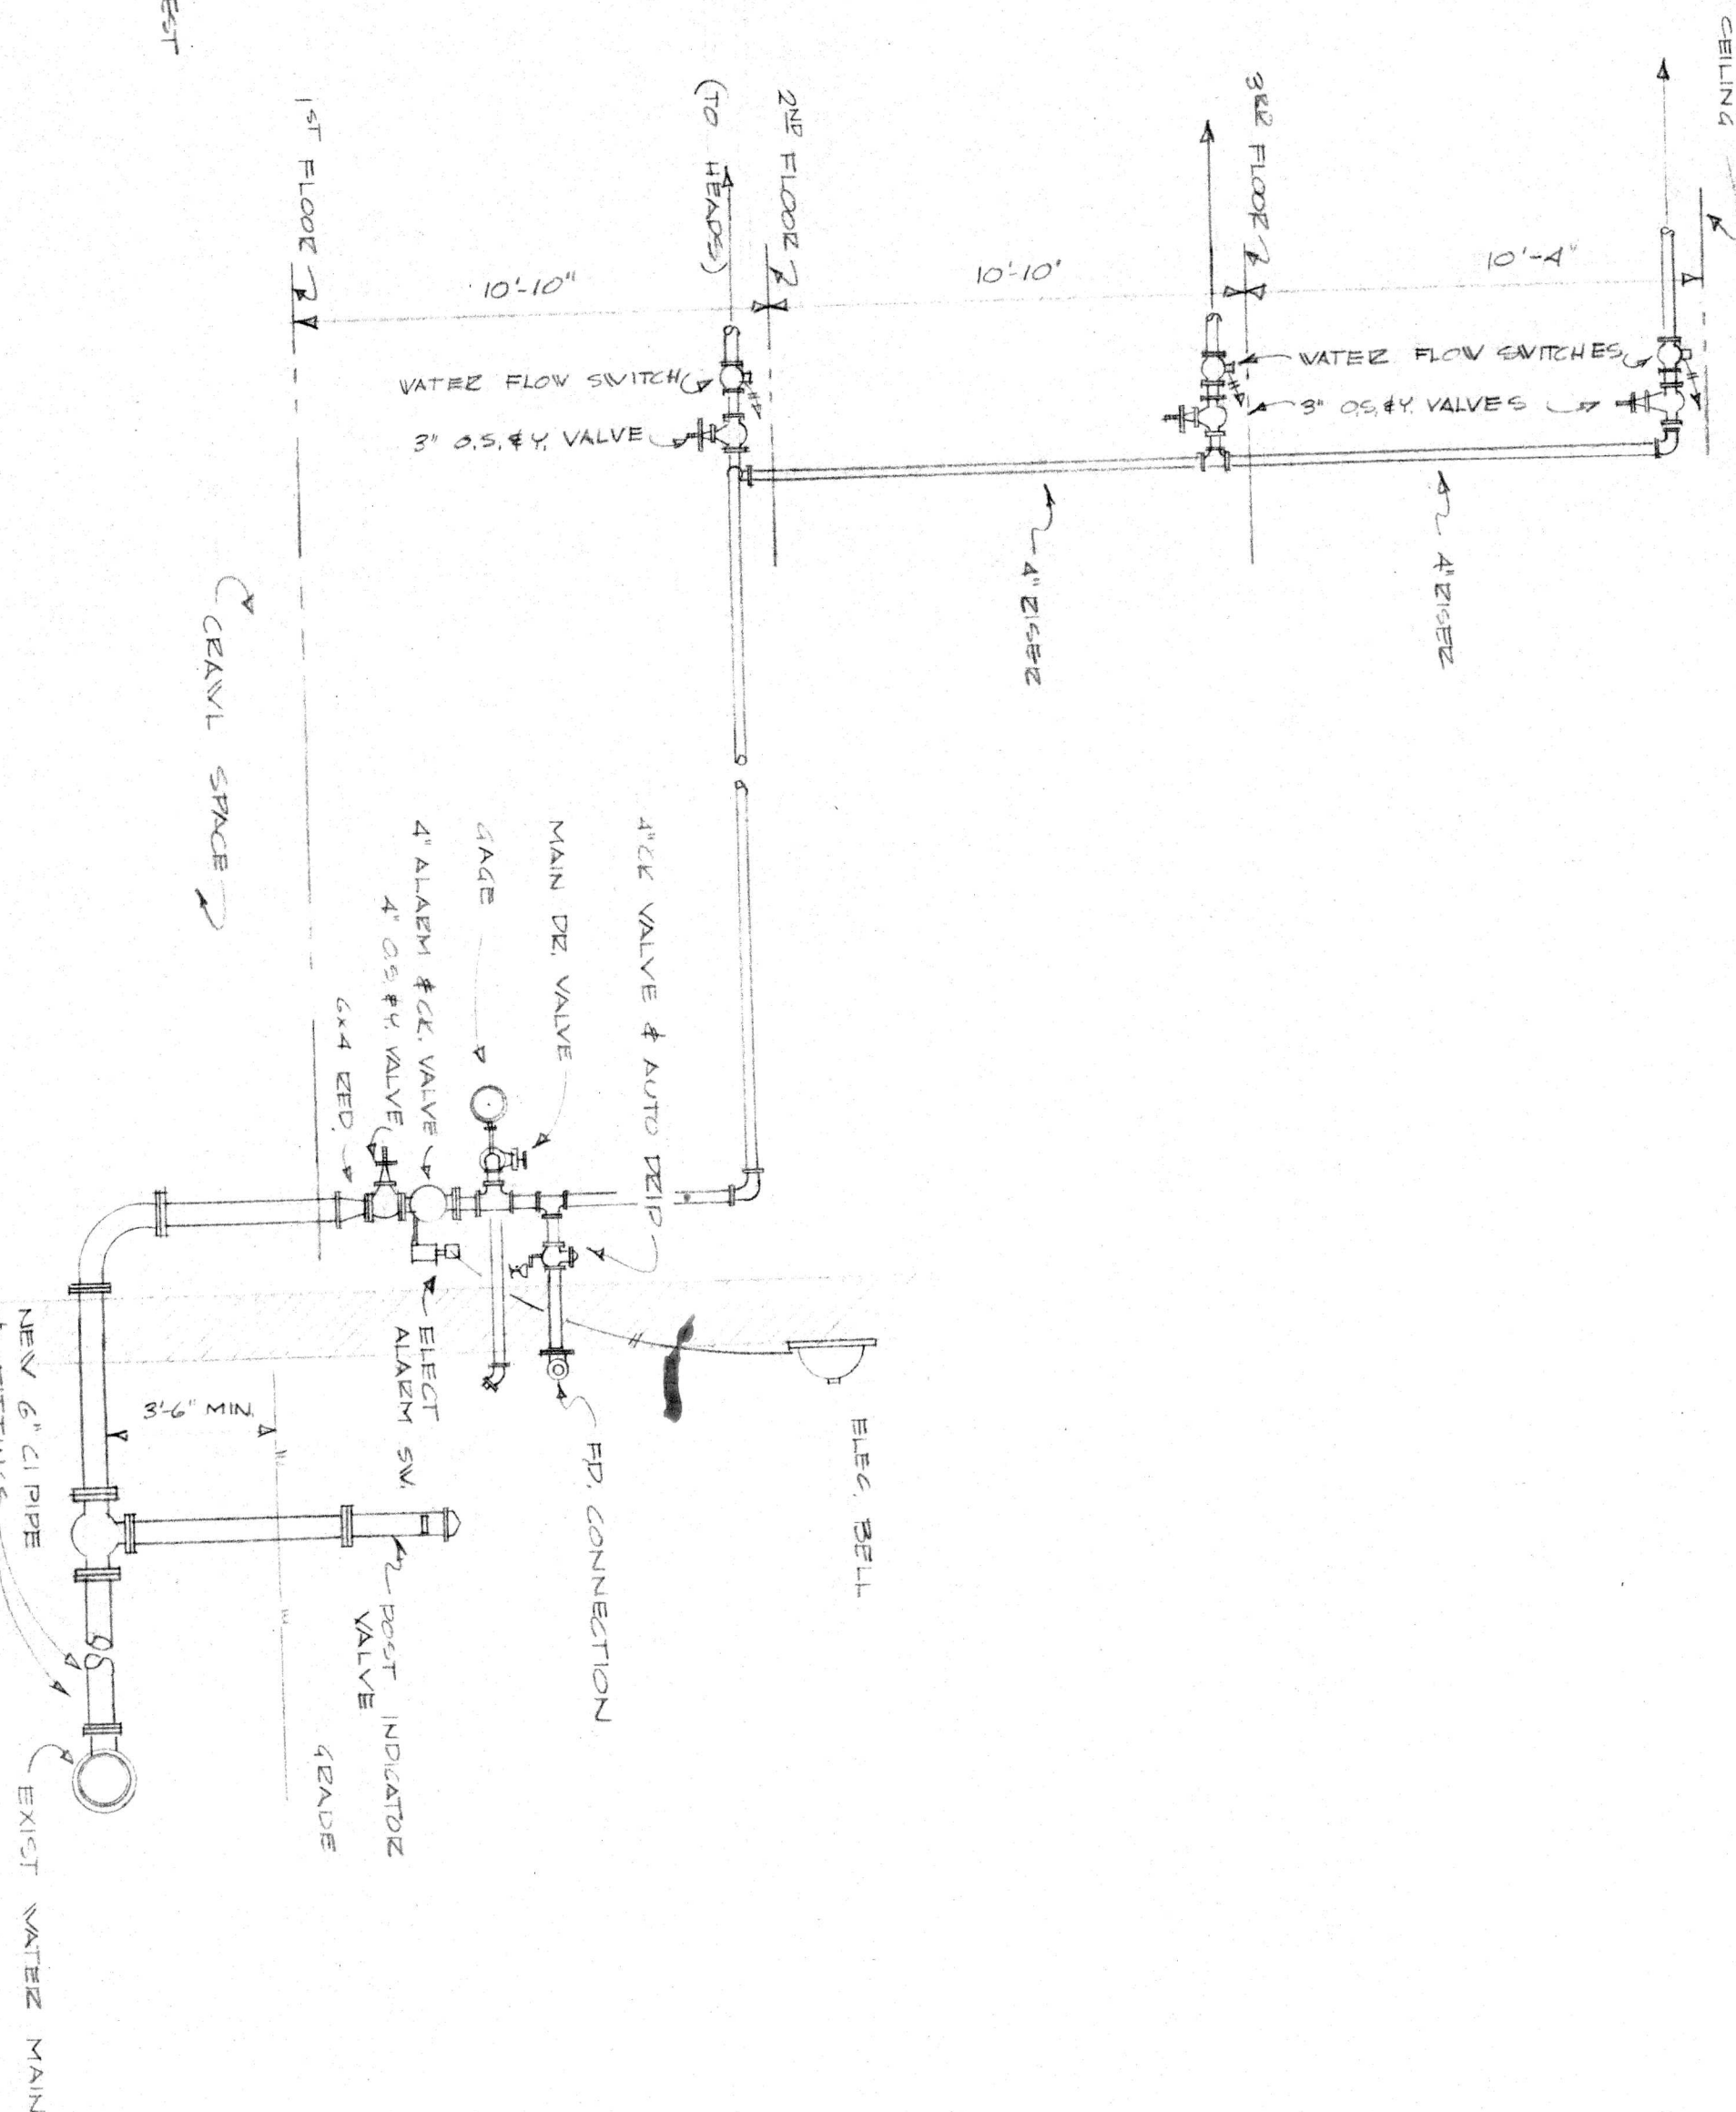

SECOND FLOOR PLAN

SCALE 1/8"=1'-0"

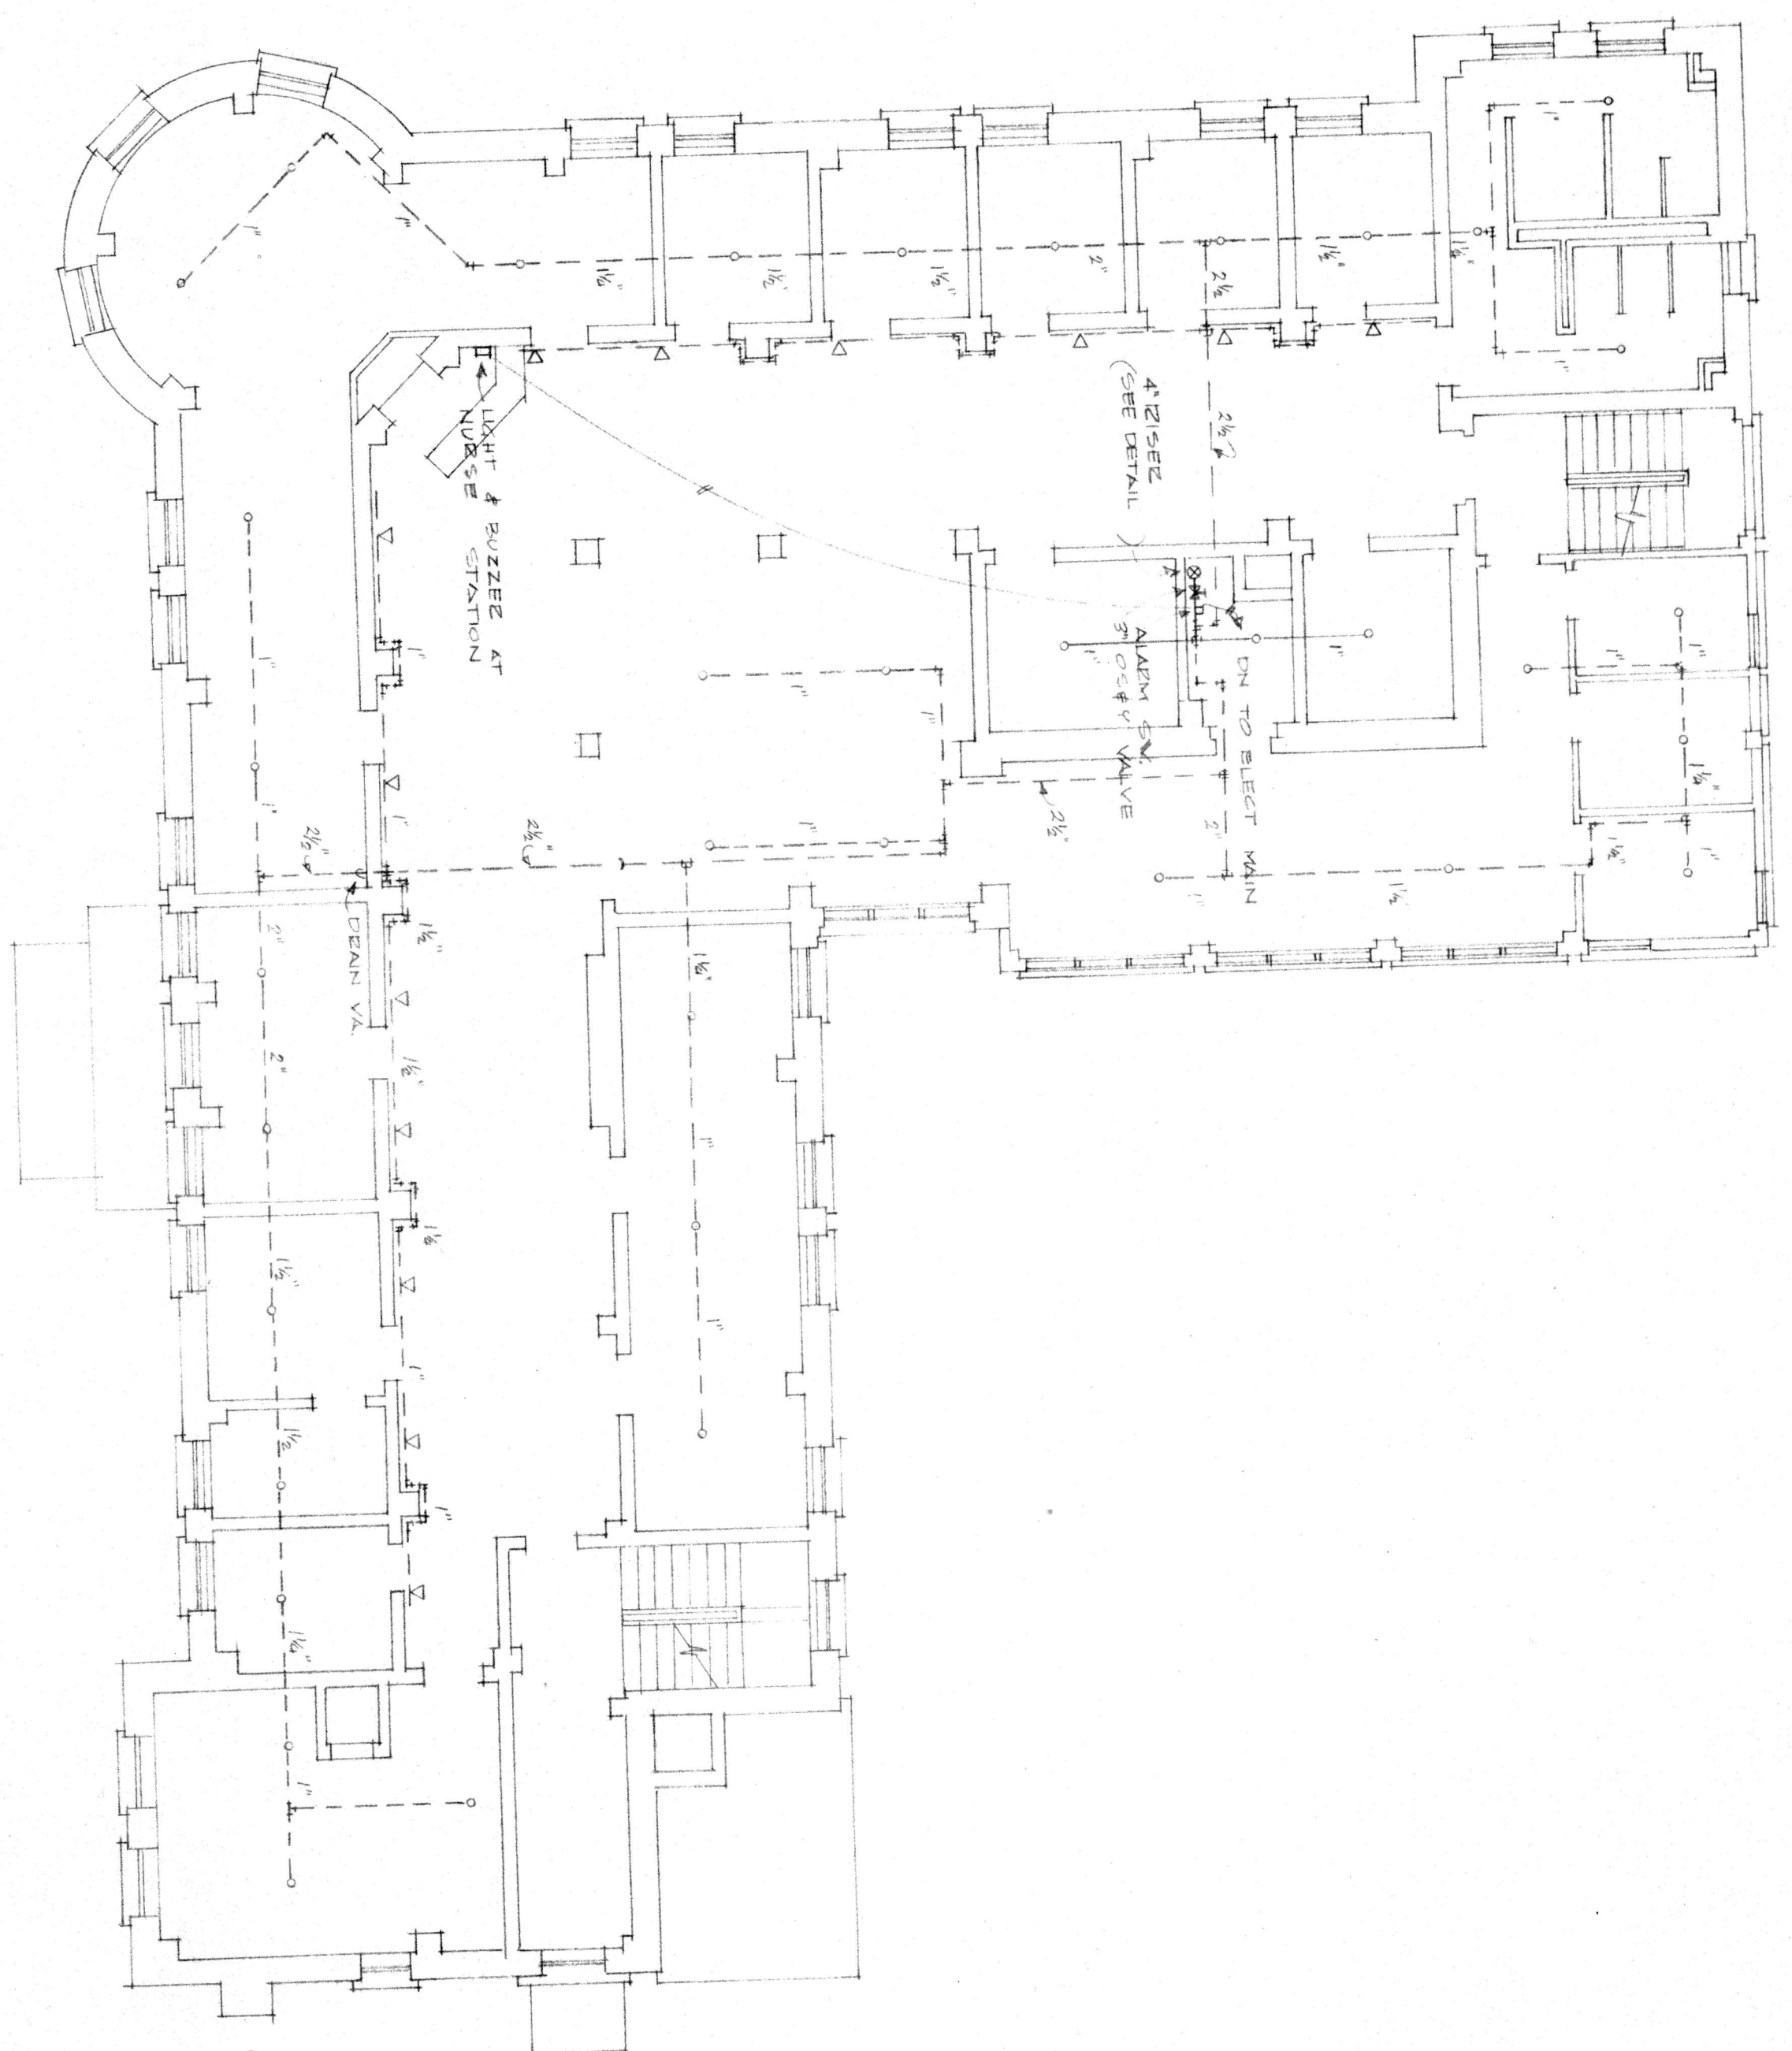

NOTES:
1. CONTRACTOR TO PROVIDE WIRE GUARD ON ALL SPRINKLER HEADS IN THE CHILD TREATMENT CENTER RECEPTION.

KEY TO SYMBOLS

- UPRIGHT SPRINKLER HEADS
- SIDEWALL SPRINKLER HEADS
- × PIPE (SIZE INDICATED) PIPES
- BASE BID SPRINKLER PIPES
- ALTERNATE BID SPRINKLER PIPES
- CONTRACTOR TO PROVIDE PIPES AT THIS SYMBOL (IN BASE BID)