



BOOSTER HEATER BY OTHERS. PLUMBING CONTRACTOR SHALL ROUGH IN & CONNECT UP. SEE DETAIL
 KITCHEN EQUIPMENT NOT IN THIS CONTRACT. PLUMBING CONTRACTOR SHALL ROUGH IN & CONNECT UP EQUIPMENT AS REQ'D. FURNISH & INSTALL TRAPS, STOPS, FLEX SUPPLY, STOP LINES, ETC. AS REQ'D.
 GREASE INTERCEPTOR BY PLUMBING CONTRACTOR TO BE SET FLUSH WITH FLOOR 35 G.P.M. TO 255 G.A.P.

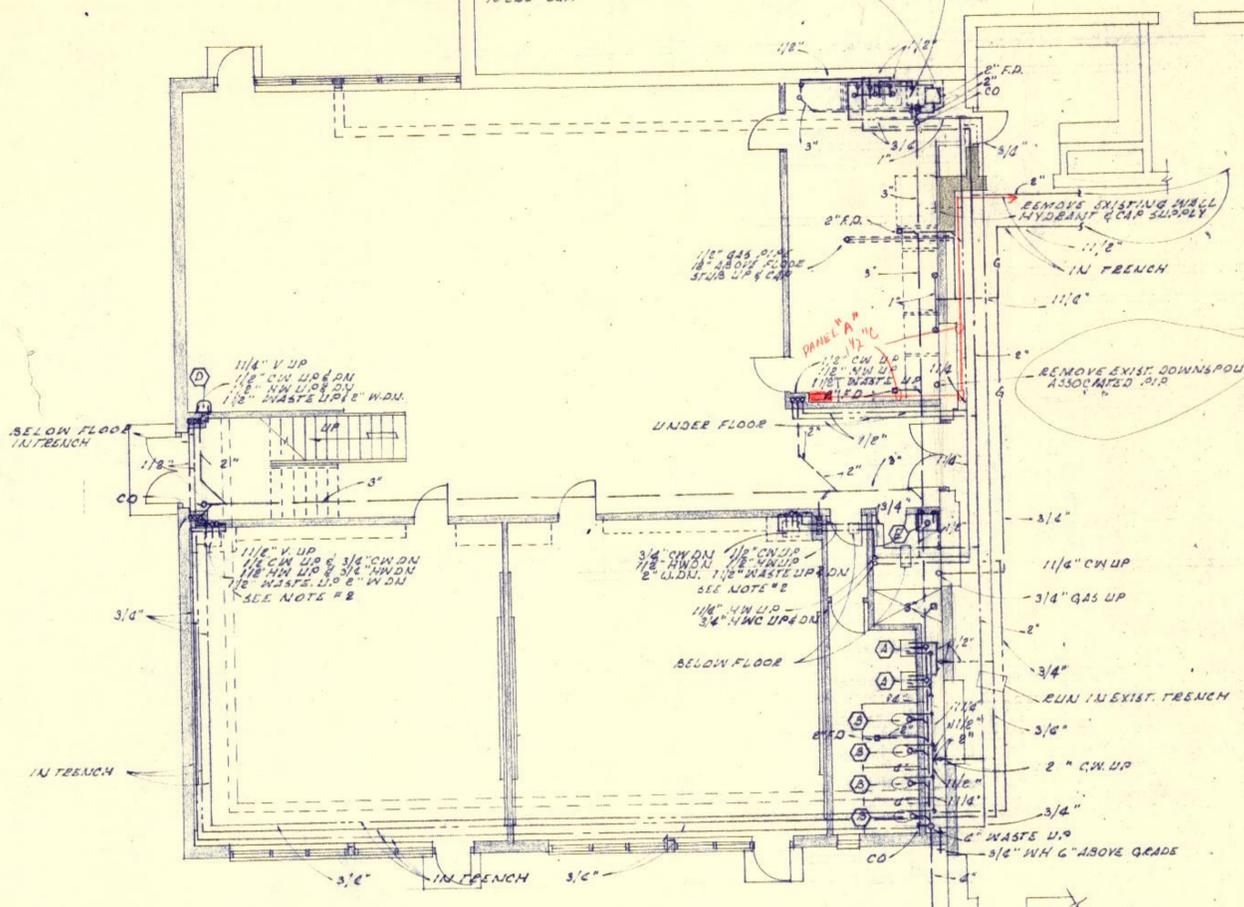


GROUND FLOOR PLAN
 SCALE 1/8" = 1'-0"

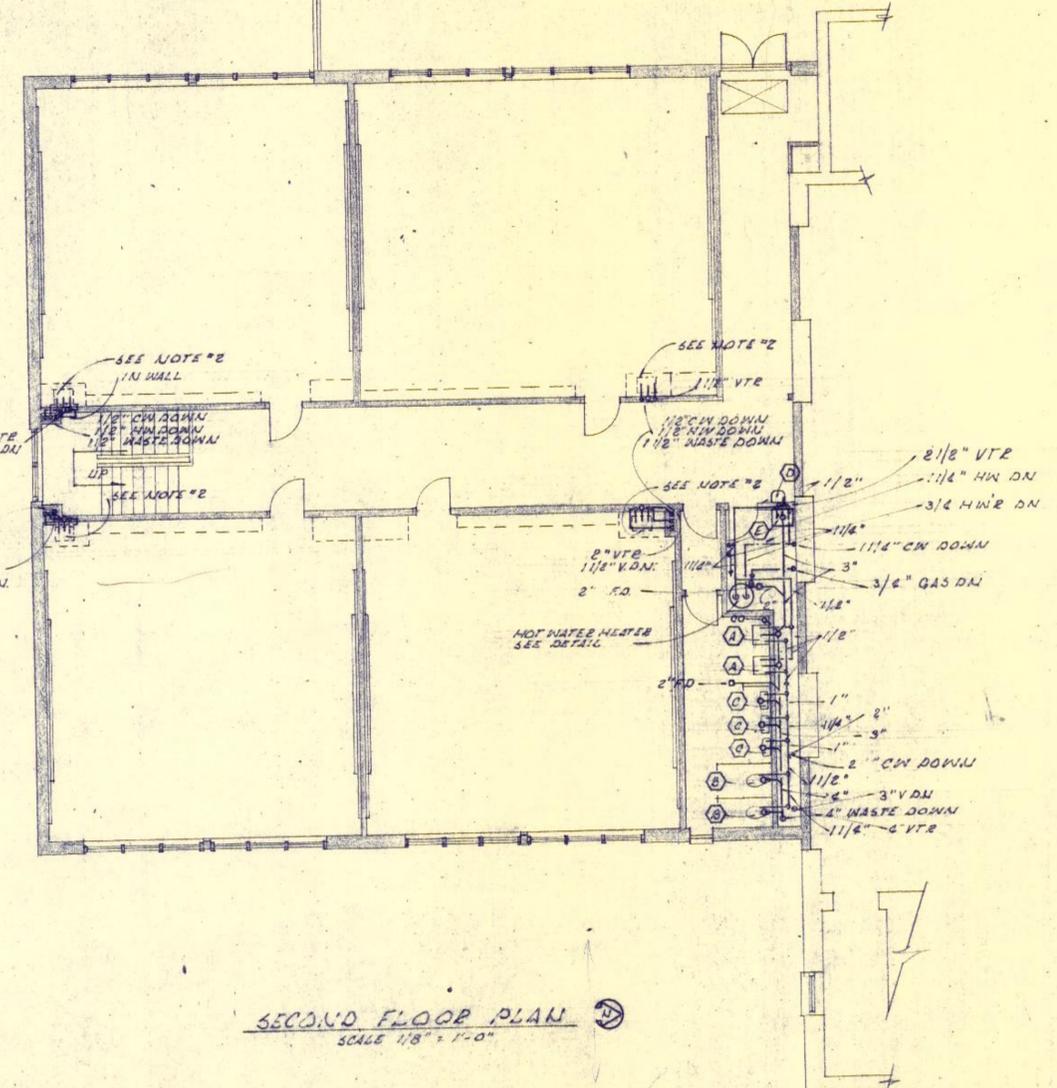


SECOND FLOOR PLAN
 SCALE 1/8" = 1'-0"

- NOTES:
- #1 FOR CONTINUATION SEE EXISTING BUILDING FLOOR PLAN
 - #2 FIXTURES BY OTHERS. PLUMBING CONTRACTOR TO ROUGH IN AND CONNECT UP SUPPLYING, TRAPS STOPS & FLEX SUPPLIES
 - #3 SEE MECHANICAL PLOT PLAN FOR CONTINUATION

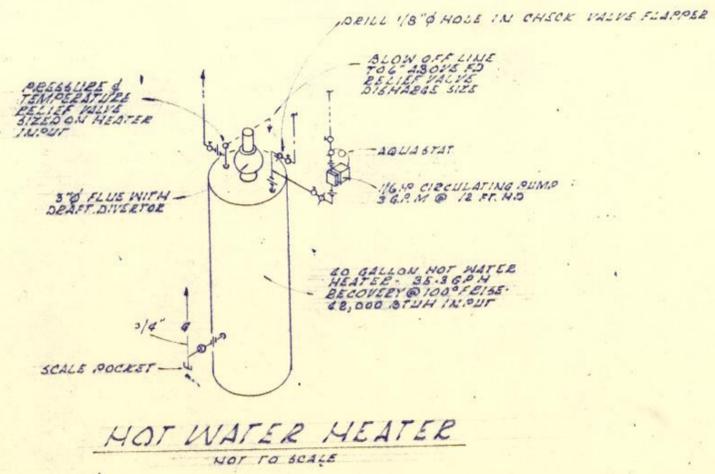

HOT WATER HEATER
 NOT TO SCALE

MECHANICAL PLOT PLAN
 SCALE 1" = 60'-0"

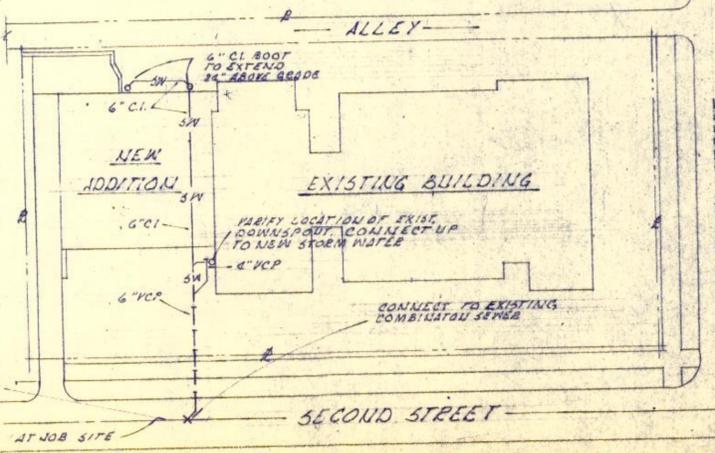

8" COMBINATION SEWER
 VERIFY LOCATION & E. AT JOB SITE

	PLUMBING PLAN & DETAILS AN ADDITION TO HUMBOLDT ELEMENTARY SCHOOL SECOND & CHERRY STREET ST. JOSEPH, MO.			SHEET NUMBER
	HERSCHMAN & DOUGLAS <i>Engineers</i> ARCHITECTS TERMINAL WAREHOUSE BUILDING - SOUTH ST. JOSEPH, MISSOURI			P-1
	MADE BY: D.E.	CH'KD. BY: P.M.	REVISED:	OF 4
	MASSAGLIA NEUSTROM MIDDLETON MECHANICAL ENGINEERS			DATE:

2007.33.2003888