
 


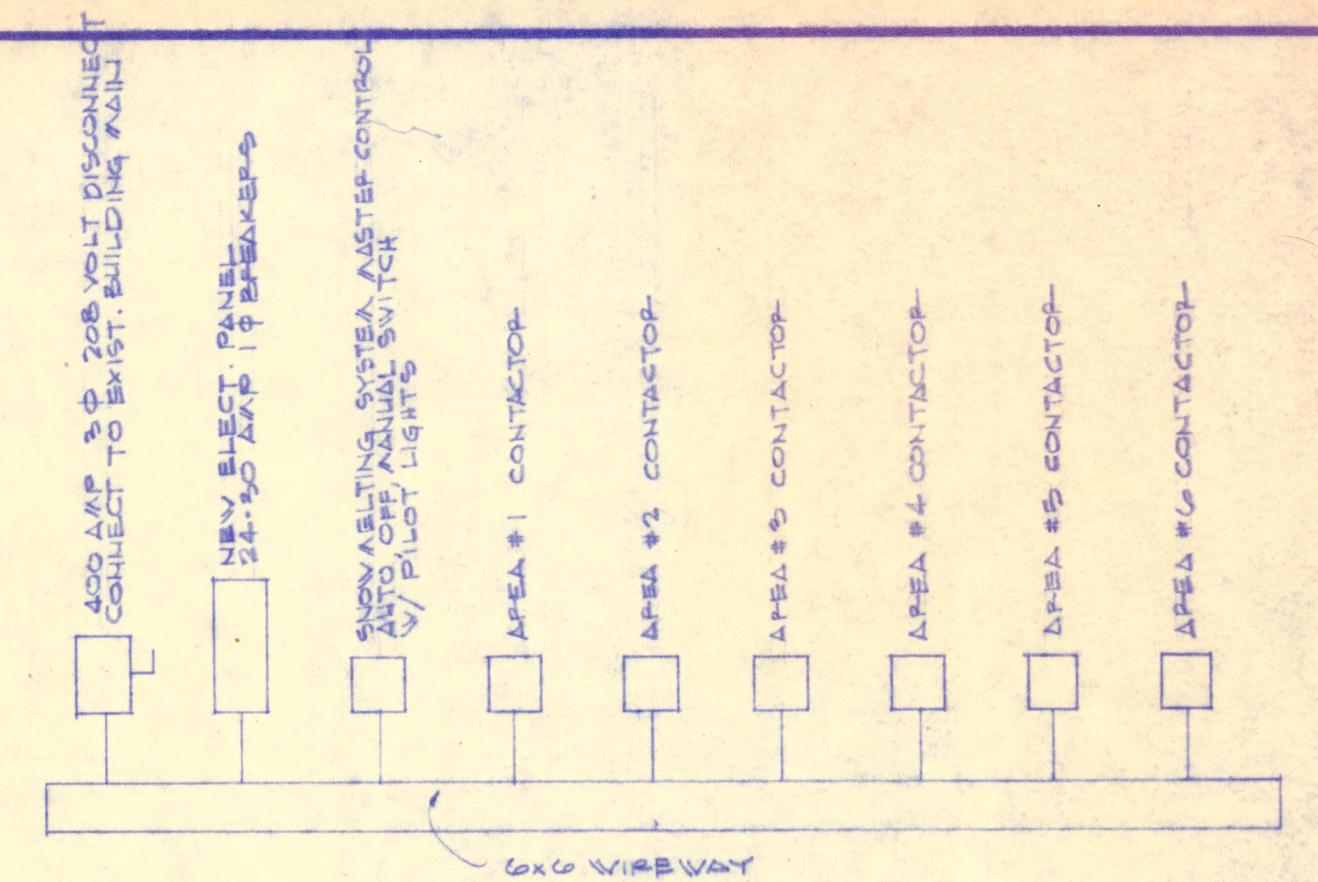


SNOW MELTING ELECTRICAL SERVICE (ALT. BID #3)
(ADJUNT IN BASEMENT EQUIP ROOM WHERE DIRECTED)


NOTE: CONNECT SHOW MELTING CABLE COLD LEADS TO CONTACTORS LOCATED IN BASEMENT OF CITY HALL BLDG.



SINGLE RAIL POST DET.
 $1\frac{1}{2}'' = 1'-0''$

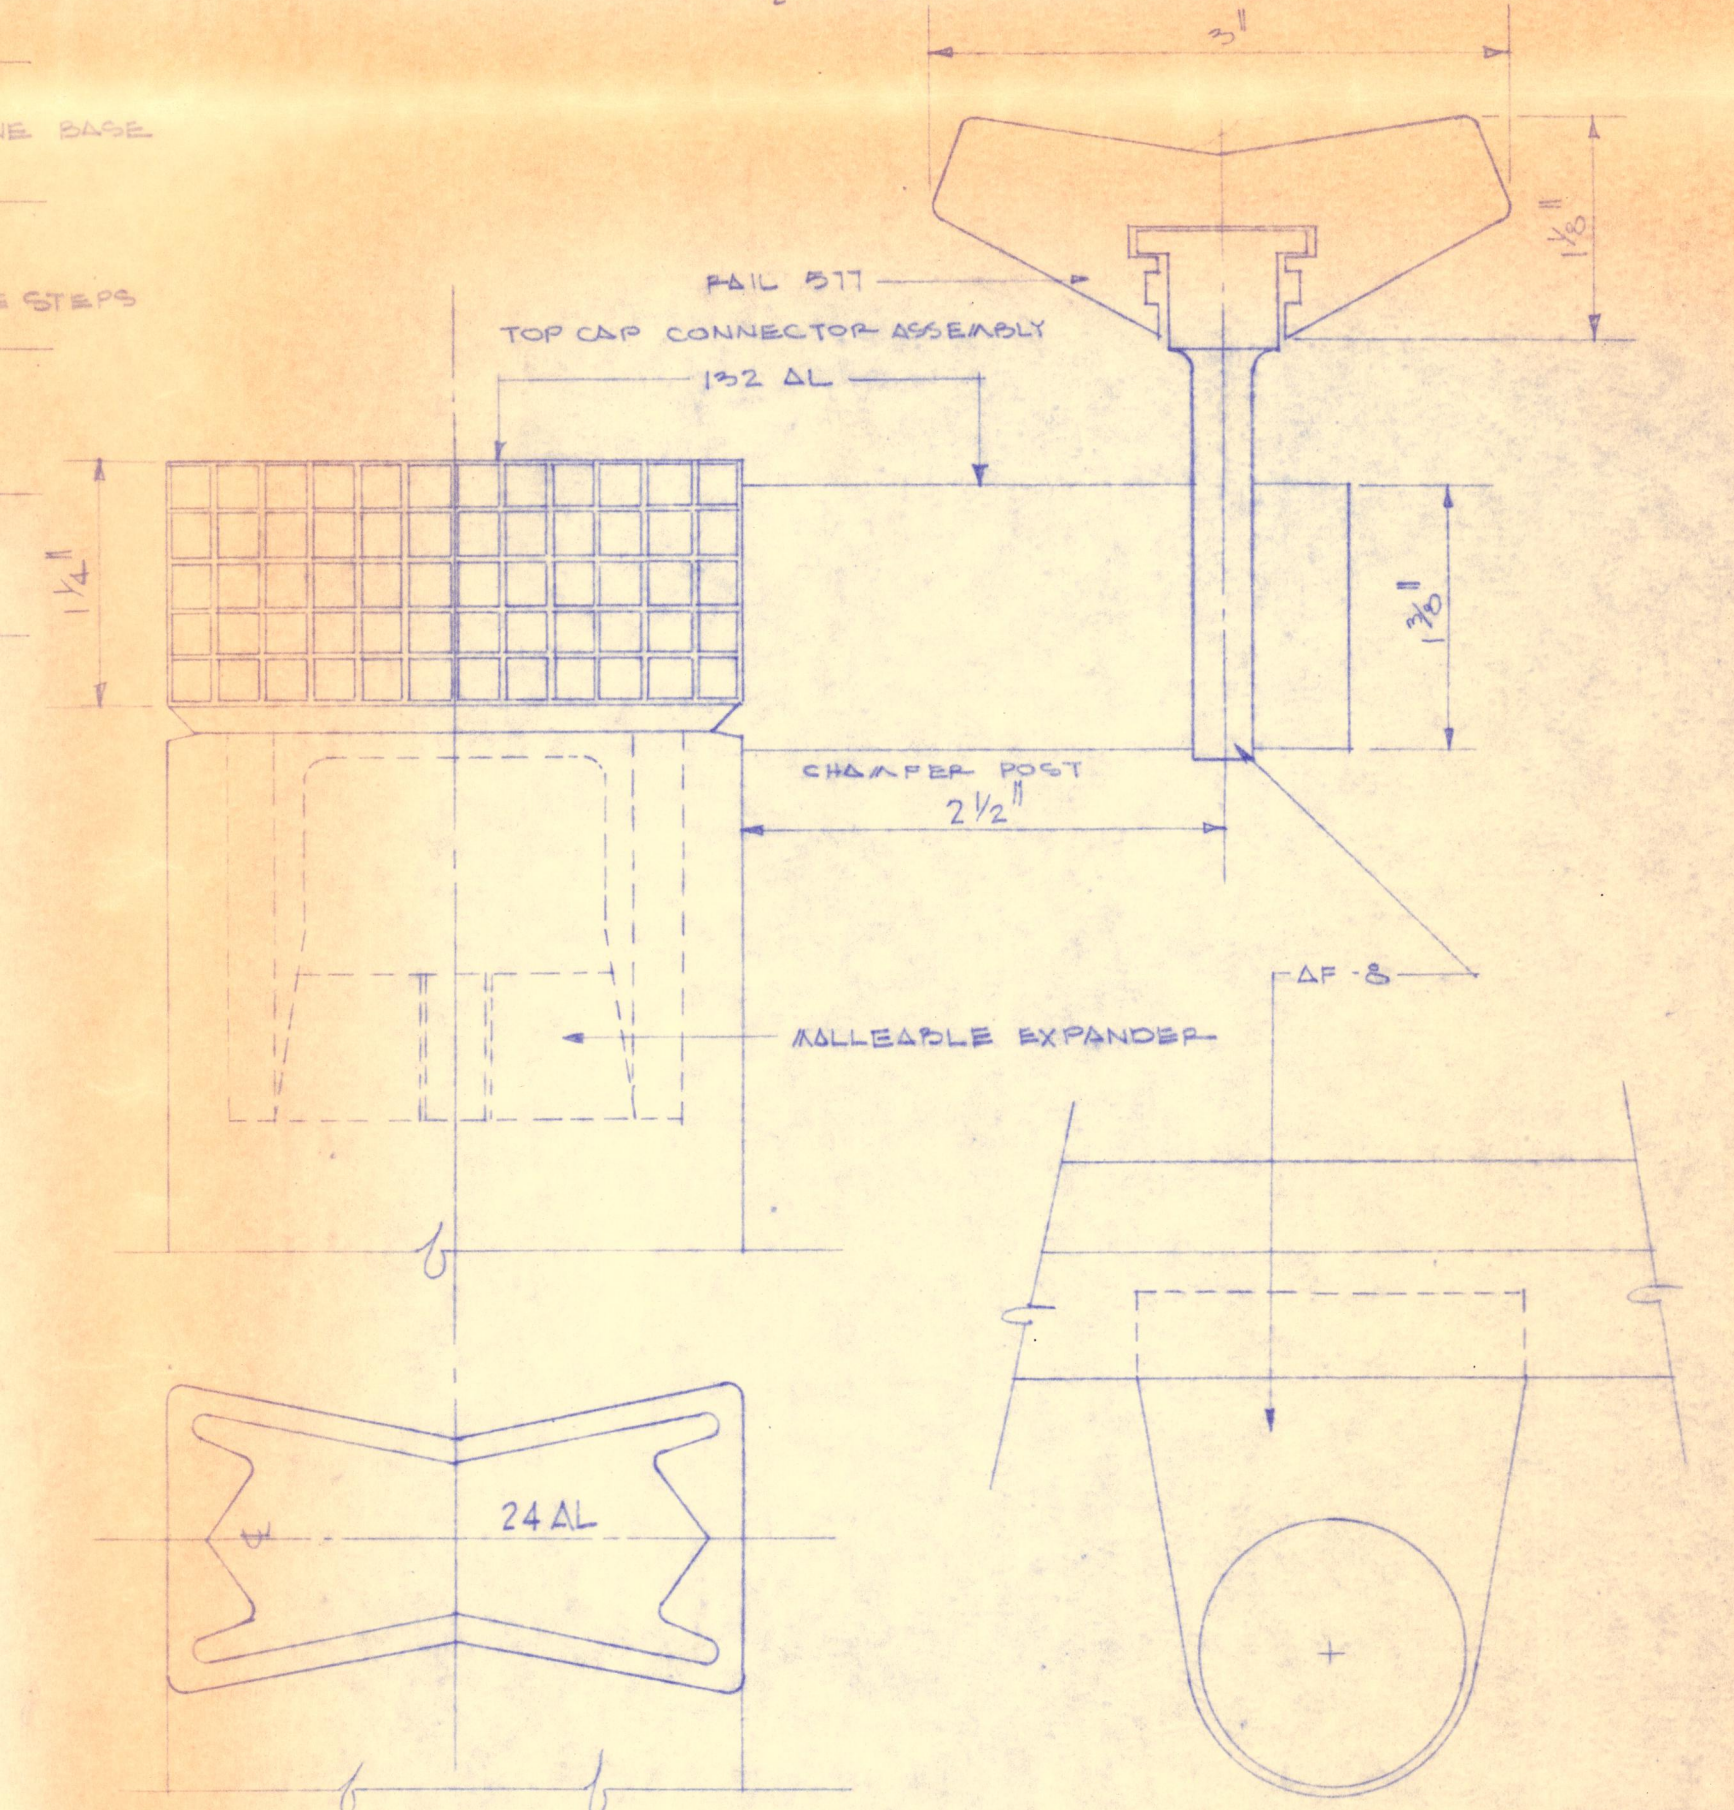

EXT. RAMP & STAIR RAILING DETAILS
FULL SCALE UNLESS NOTED OTHERWISE.

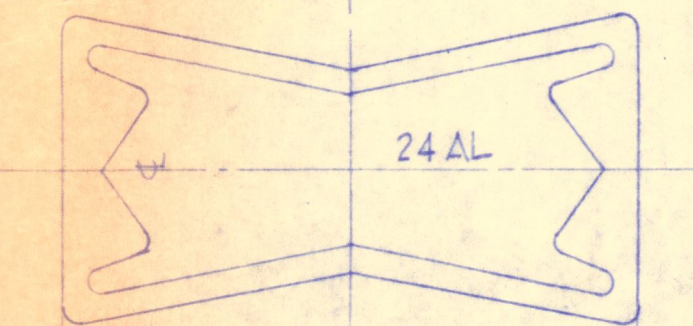

NORTH ELEVATION

RAMP DETAILS

SCALE: $\frac{1}{2}'' = 1'-0''$

(RAMP INCLUDED IN)
(ALT. BID #1)



DRAWN BY		FUSTON	
CH'KD BY		W. A. B.	
REVISION			
24 OCT. '73			

BRUNNER & BRUN
1105 CORBY BUILDING

RENOVATION OF THE EXTERIOR
OF THE
CITY HALL
FOR THE
CITY OF ST. JOSEPH, MO.
ER ARCHITECTS & ENGINEER
ST. JOSEPH, MO.

DATE 14 SEPT. '73

JOB No.

SHEET No. 2