
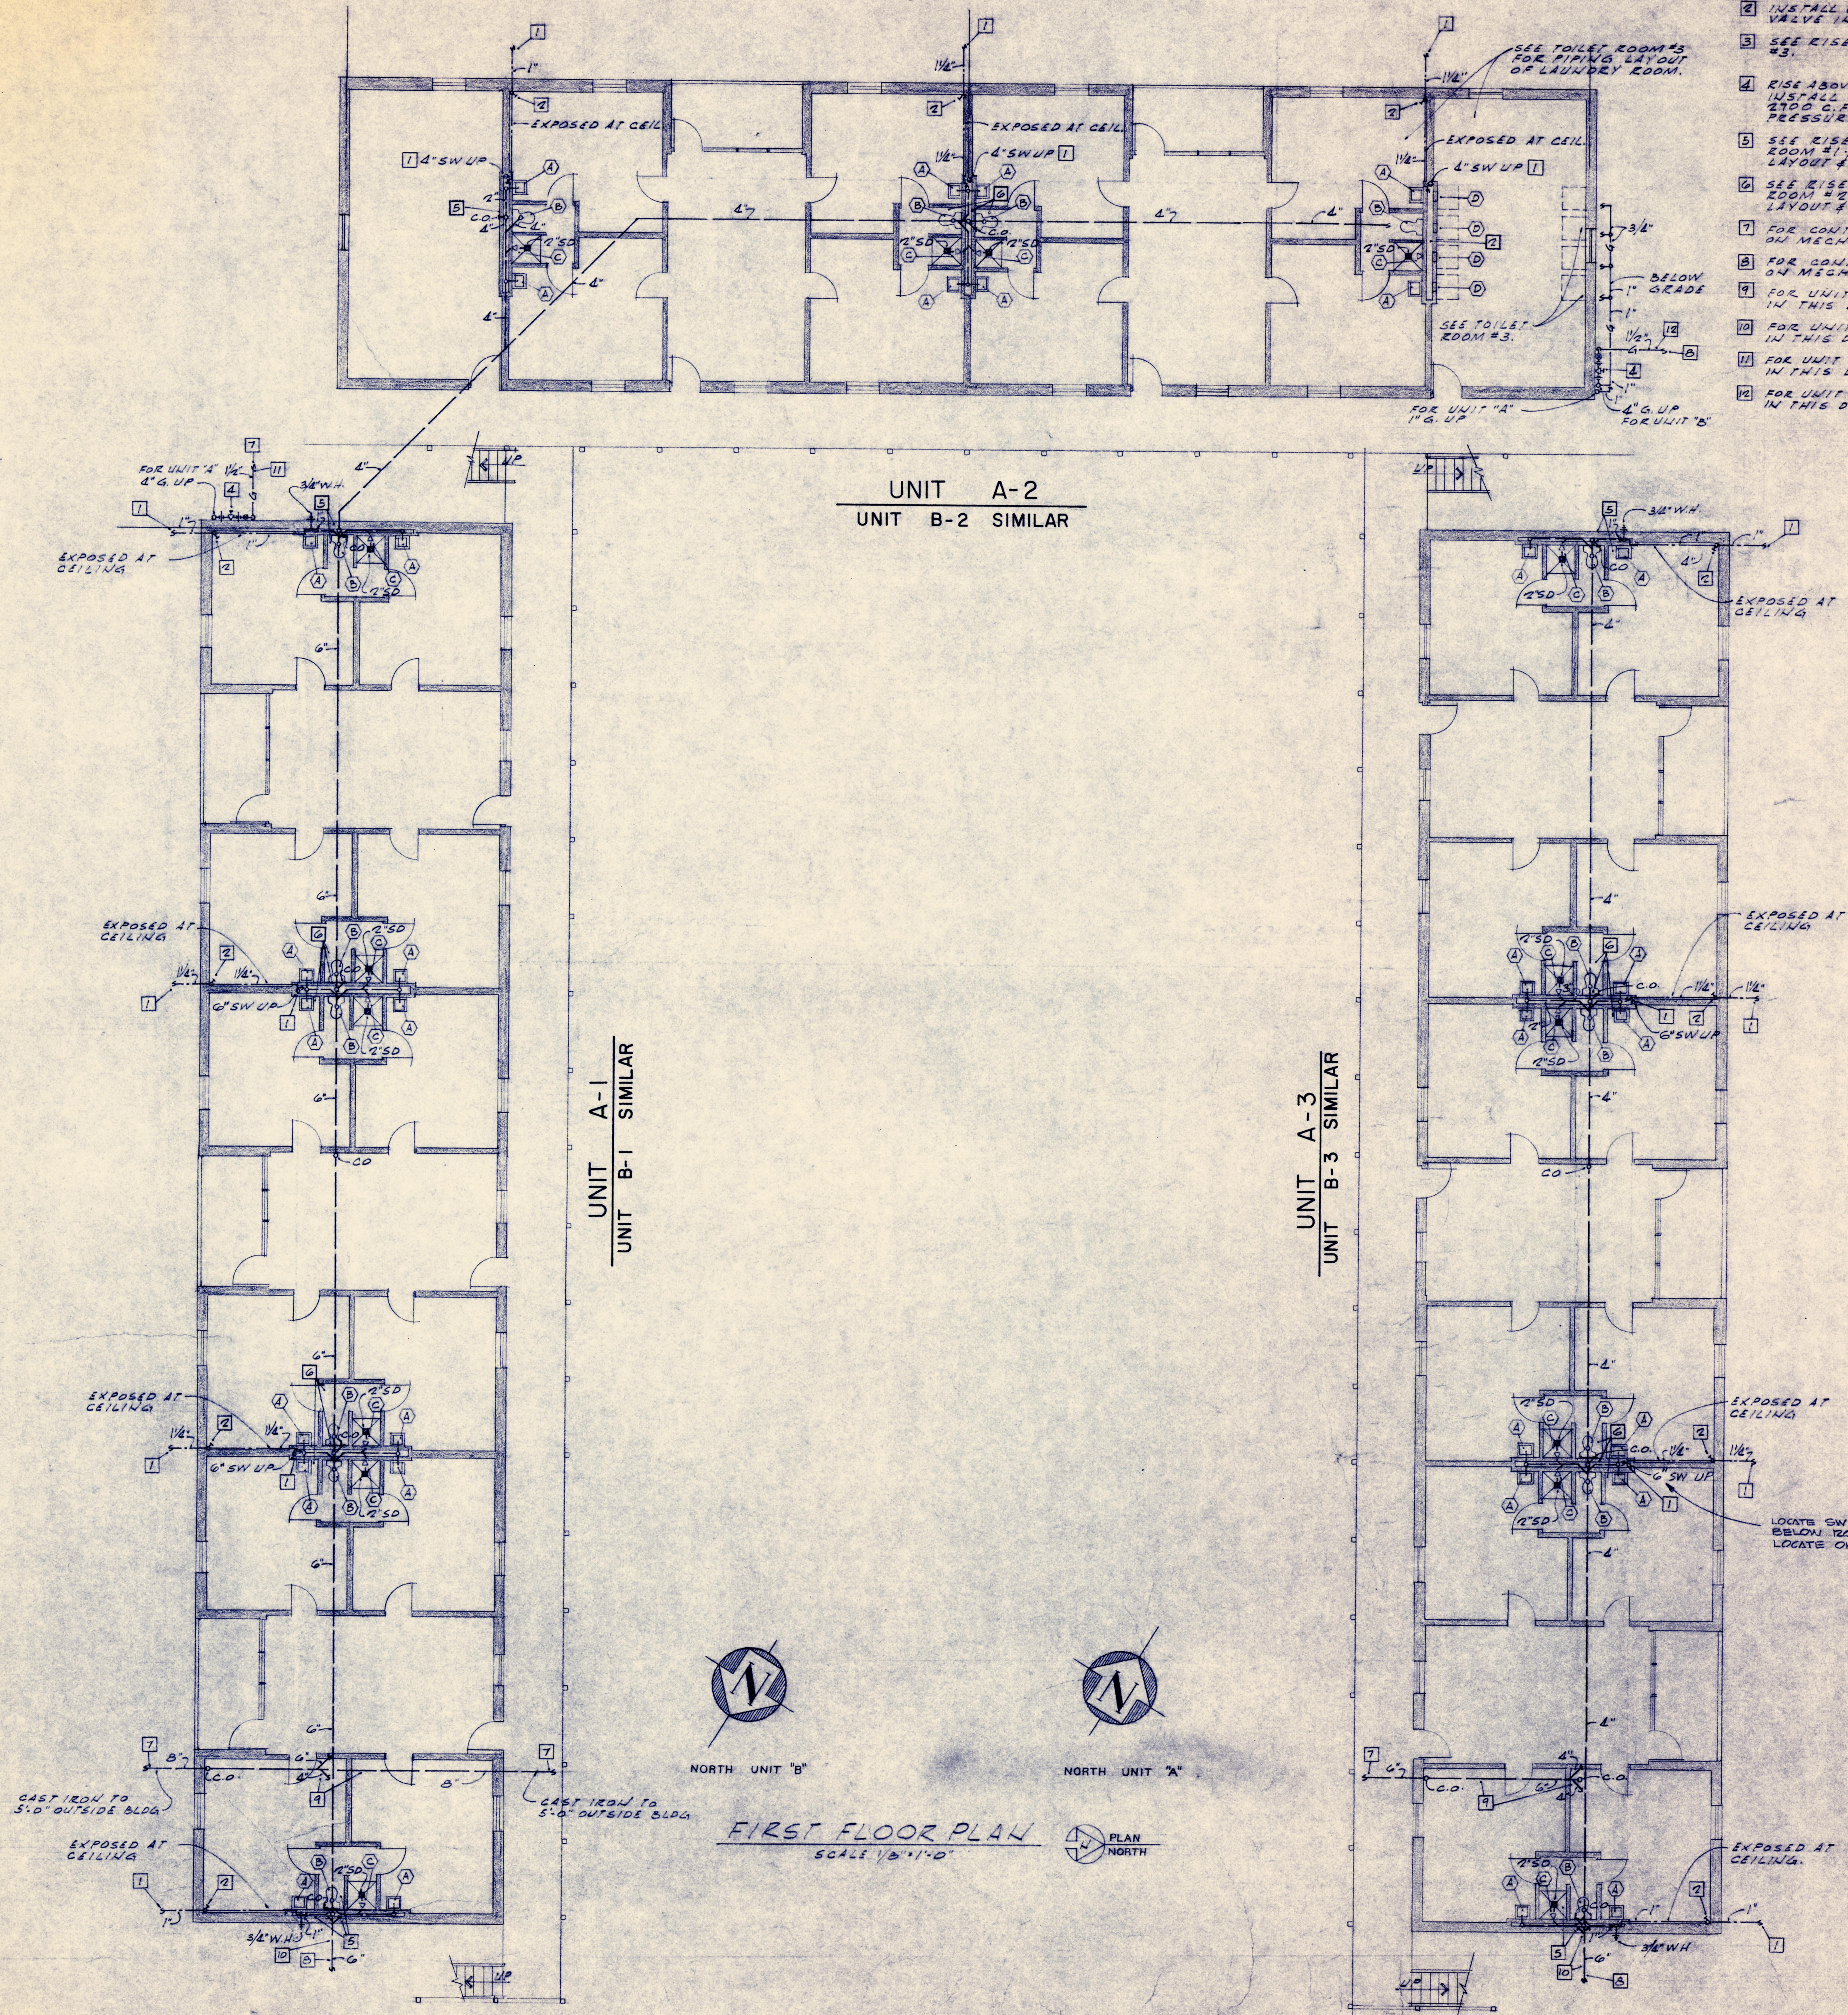
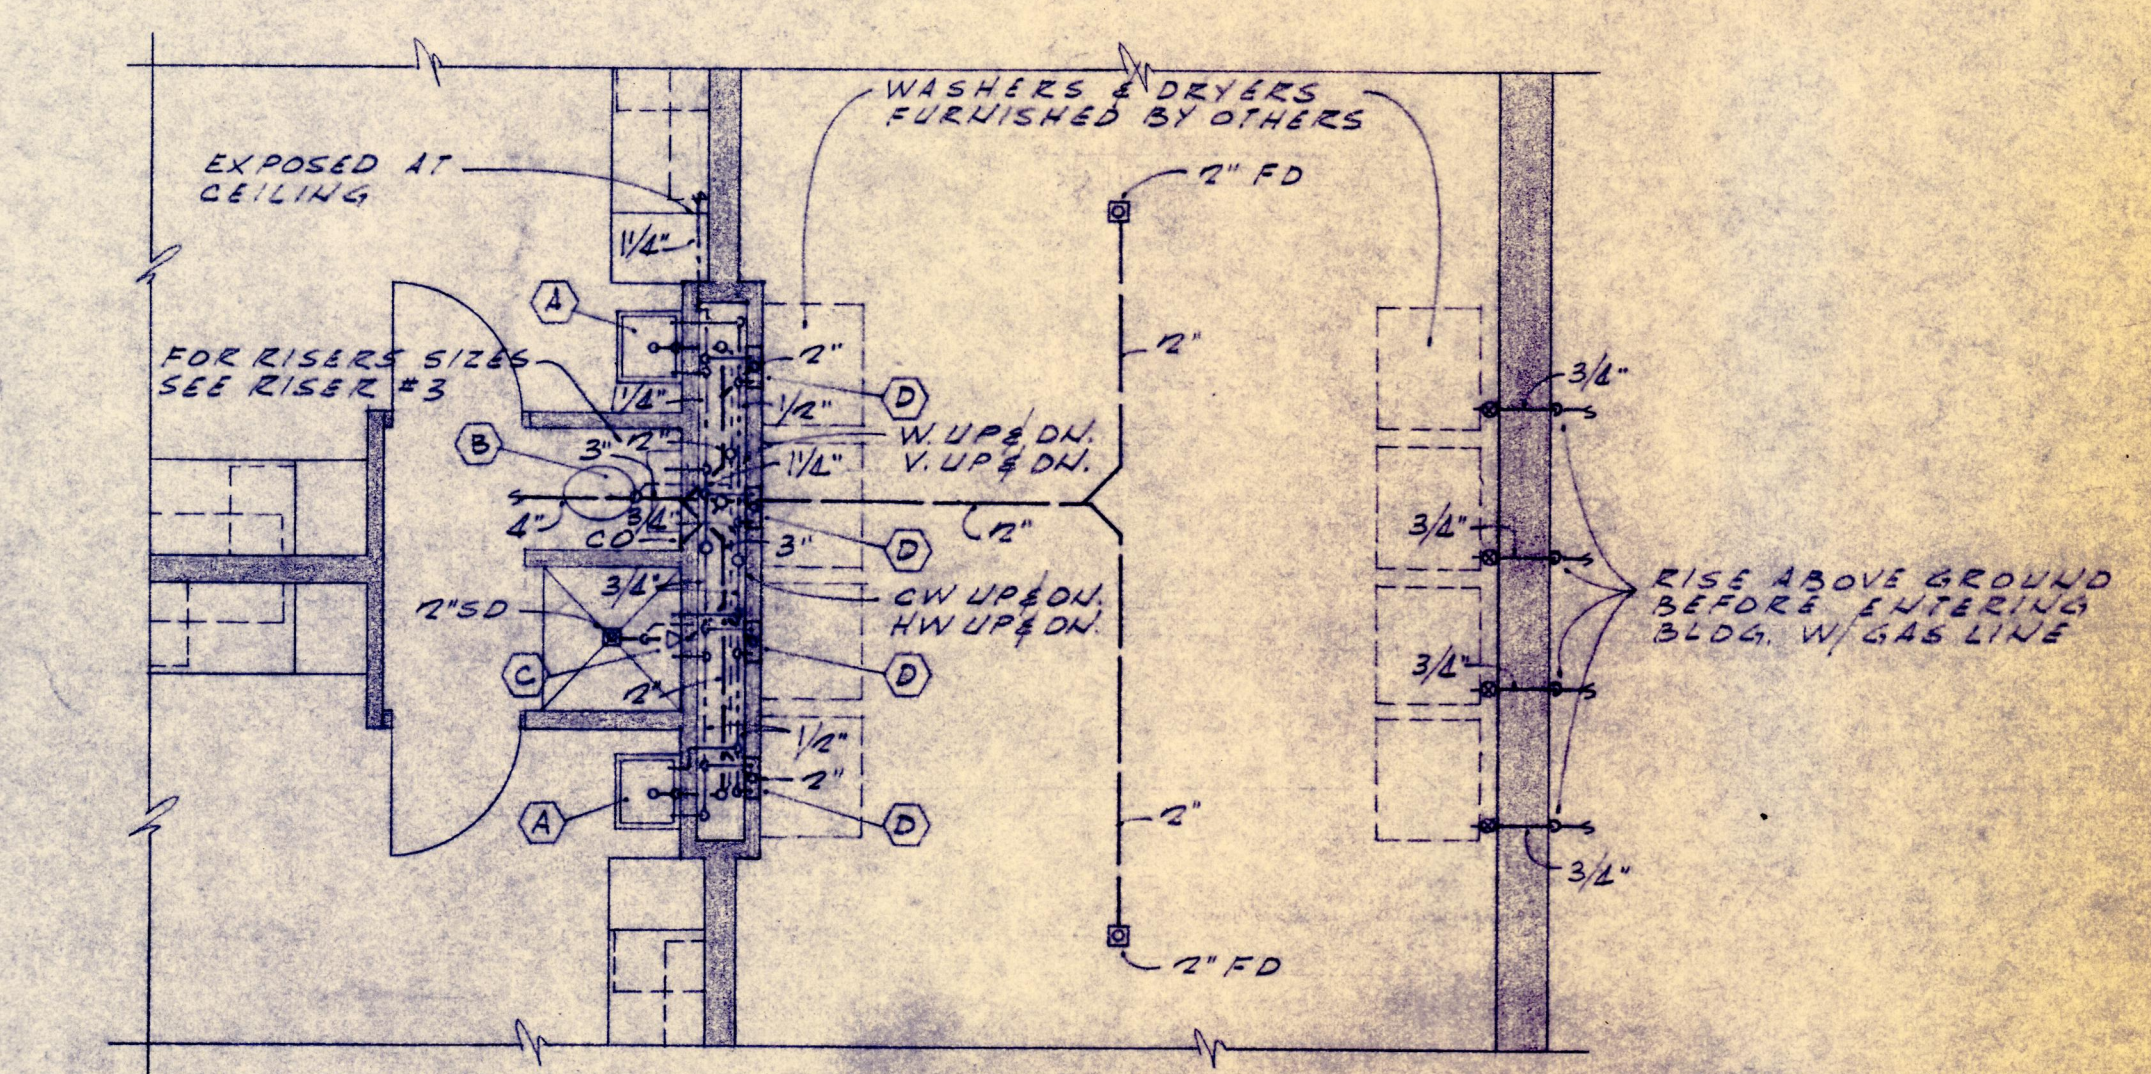
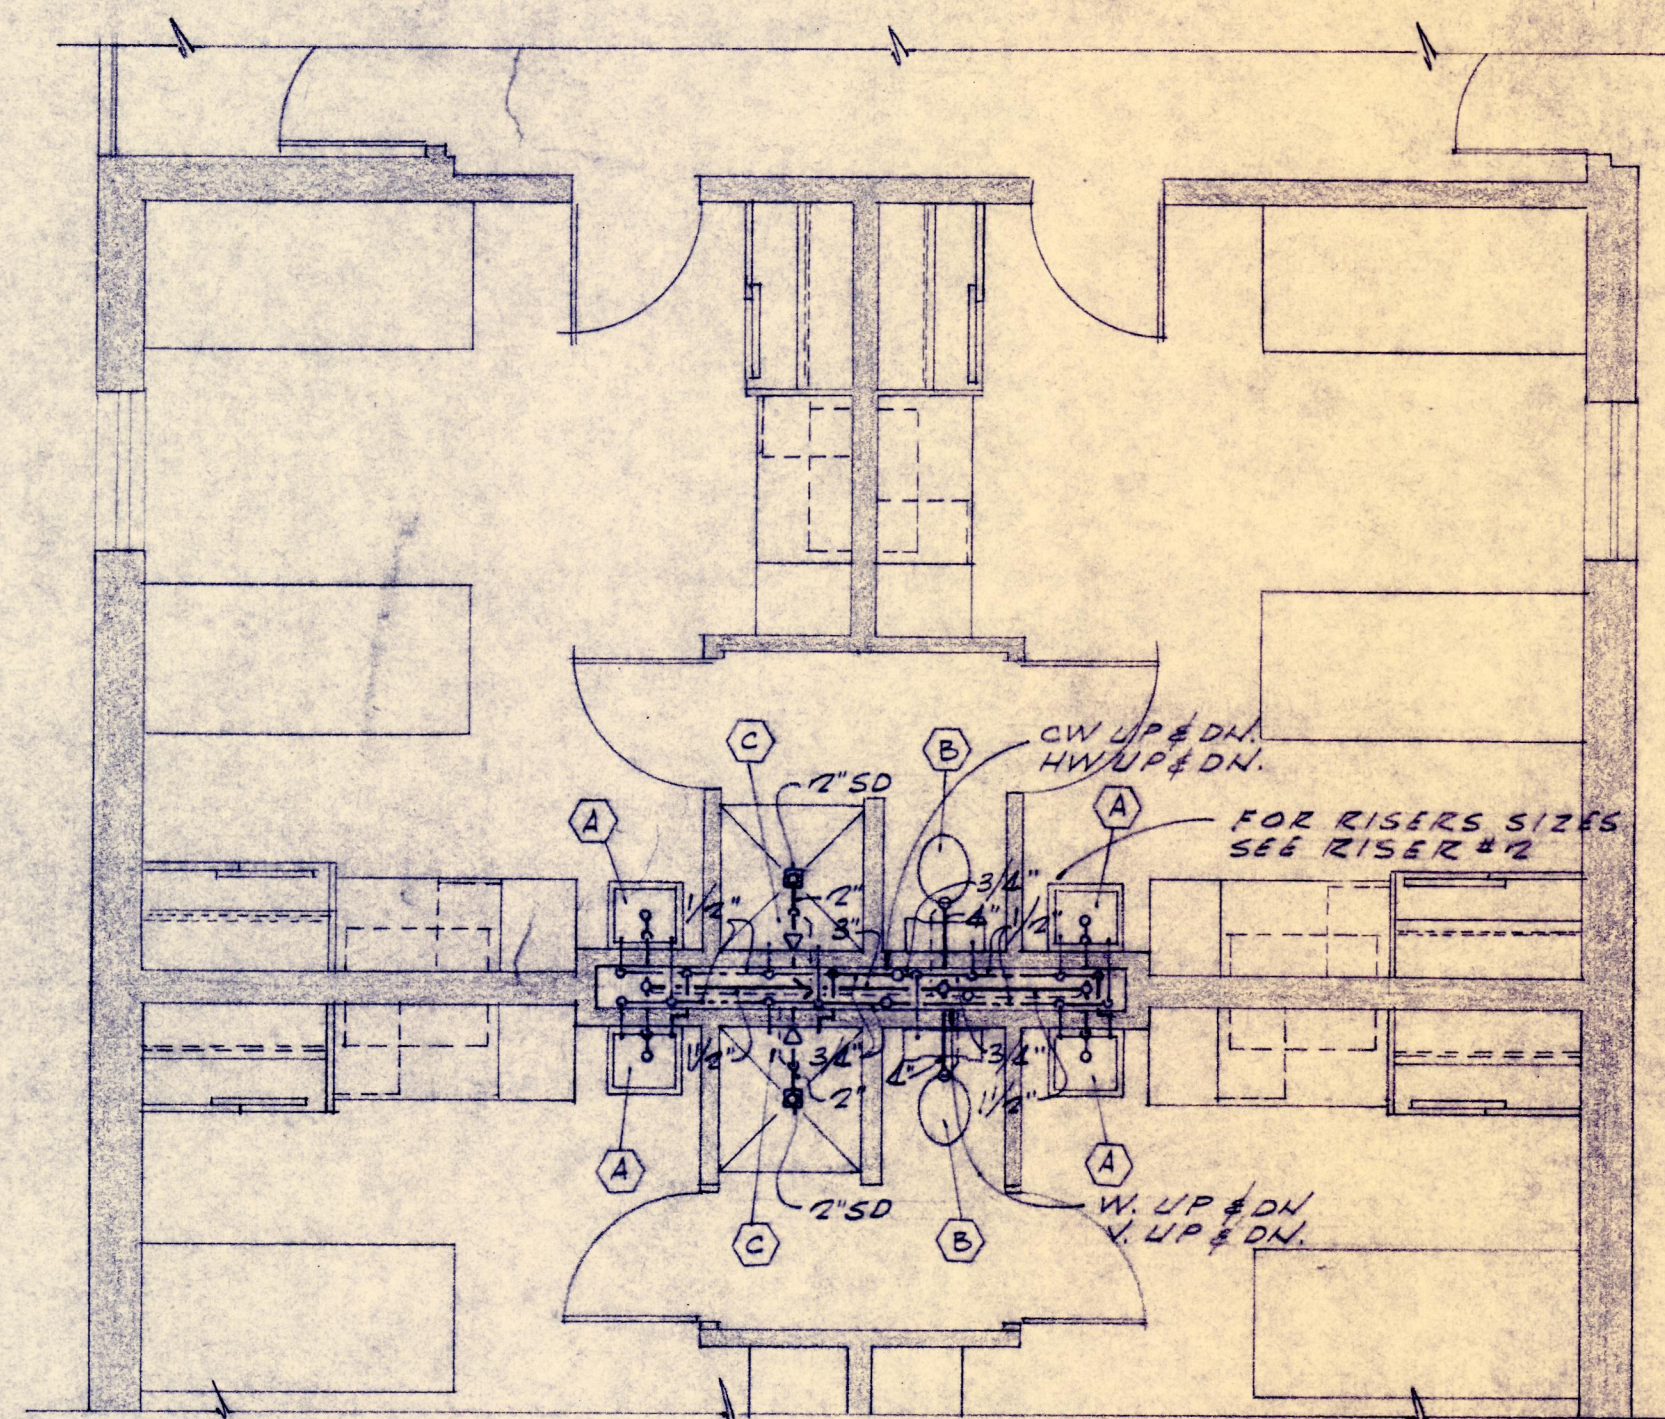


- NOTES:**
1. FOR CONTINUATION SEE MECHANICAL SITE PLAN.
 2. INSTALL COLD WATER SHUT-OFF VALVE IN RISER.
 3. SEE RISER #3 & TOILET ROOM #3.
 4. RISE ABOVE GROUND W/ GAS LINE & INSTALL GAS PRESSURE REGULATOR 2500 C.F.H. CAPACITY - 20" INITIAL PRESSURE - 0.02" FINAL PRESSURE.
 5. SEE RISER #1 & TYPICAL TOILET ROOM #1 FOR SIMILAR PIPING LAYOUT & SIZING.
 6. SEE RISER #2 & TYPICAL TOILET ROOM #2 FOR SIMILAR PIPING LAYOUT & SIZING.
 7. FOR CONTINUATION SEE UNIT "A" ON MECHANICAL SITE PLAN.
 8. FOR CONTINUATION SEE UNIT "B" ON MECHANICAL SITE PLAN.
 9. FOR UNIT "A" ROUTE WASTE PIPING IN THIS DIRECTION.
 10. FOR UNIT "B" ROUTE WASTE PIPING IN THIS DIRECTION.
 11. FOR UNIT "A" ROUTE GAS PIPING IN THIS DIRECTION.
 12. FOR UNIT "B" ROUTE GAS PIPING IN THIS DIRECTION.

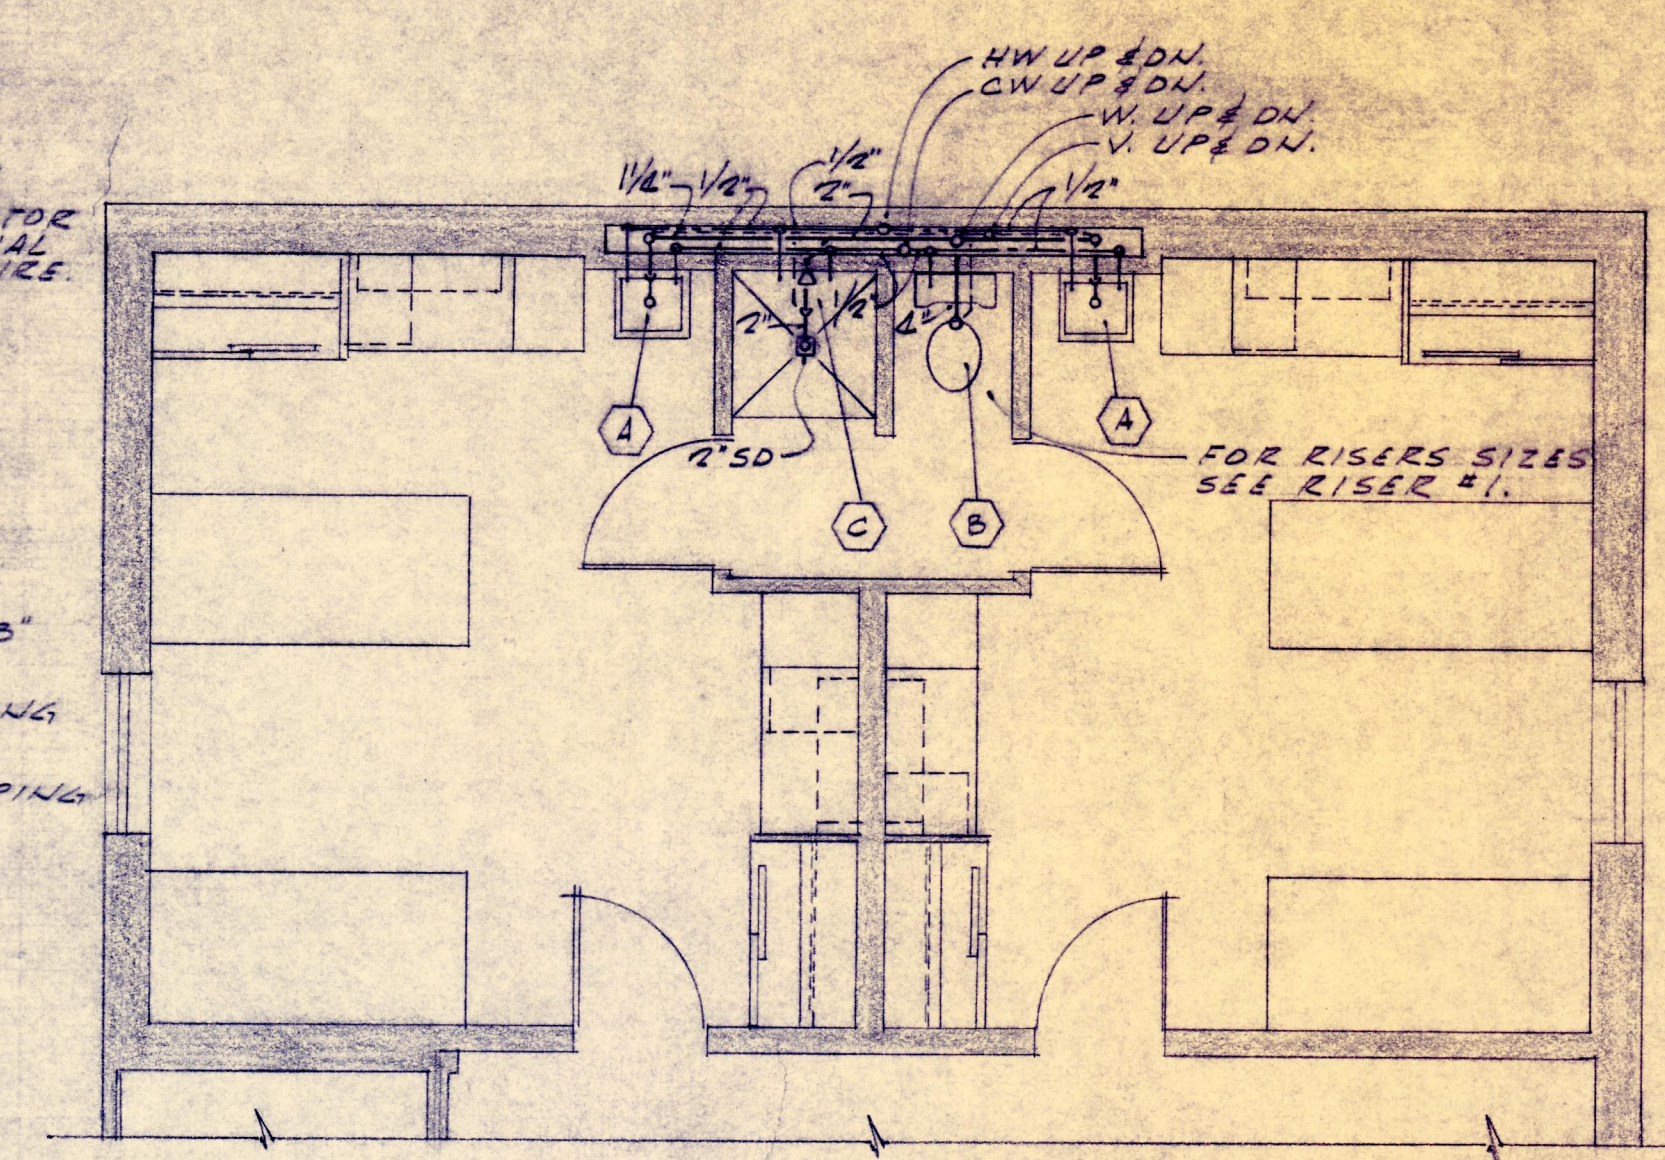

PROJECT NO. CH. MO. 159 (C) 2001.33.2324.0

PLUMBING - FIRST FLOOR PLAN

384 STUDENT DORMITORY
MISSOURI WESTERN COLLEGE
ST. JOSEPH, MISSOURI

HERSCHMAN & DOUGLAS
Engineers
1311 VILLAGE DRIVE - ST. JOSEPH, MISSOURI

MADE BY: R.A.G. CH'KD. BY: H.M.V. REVISED: _____

MASSACHUSETTS - NEUSTROM-MIDDLETON MECHANICAL ENGINEERS

SHEET NUMBER 1 OF 3 DATE: 8-15-71