
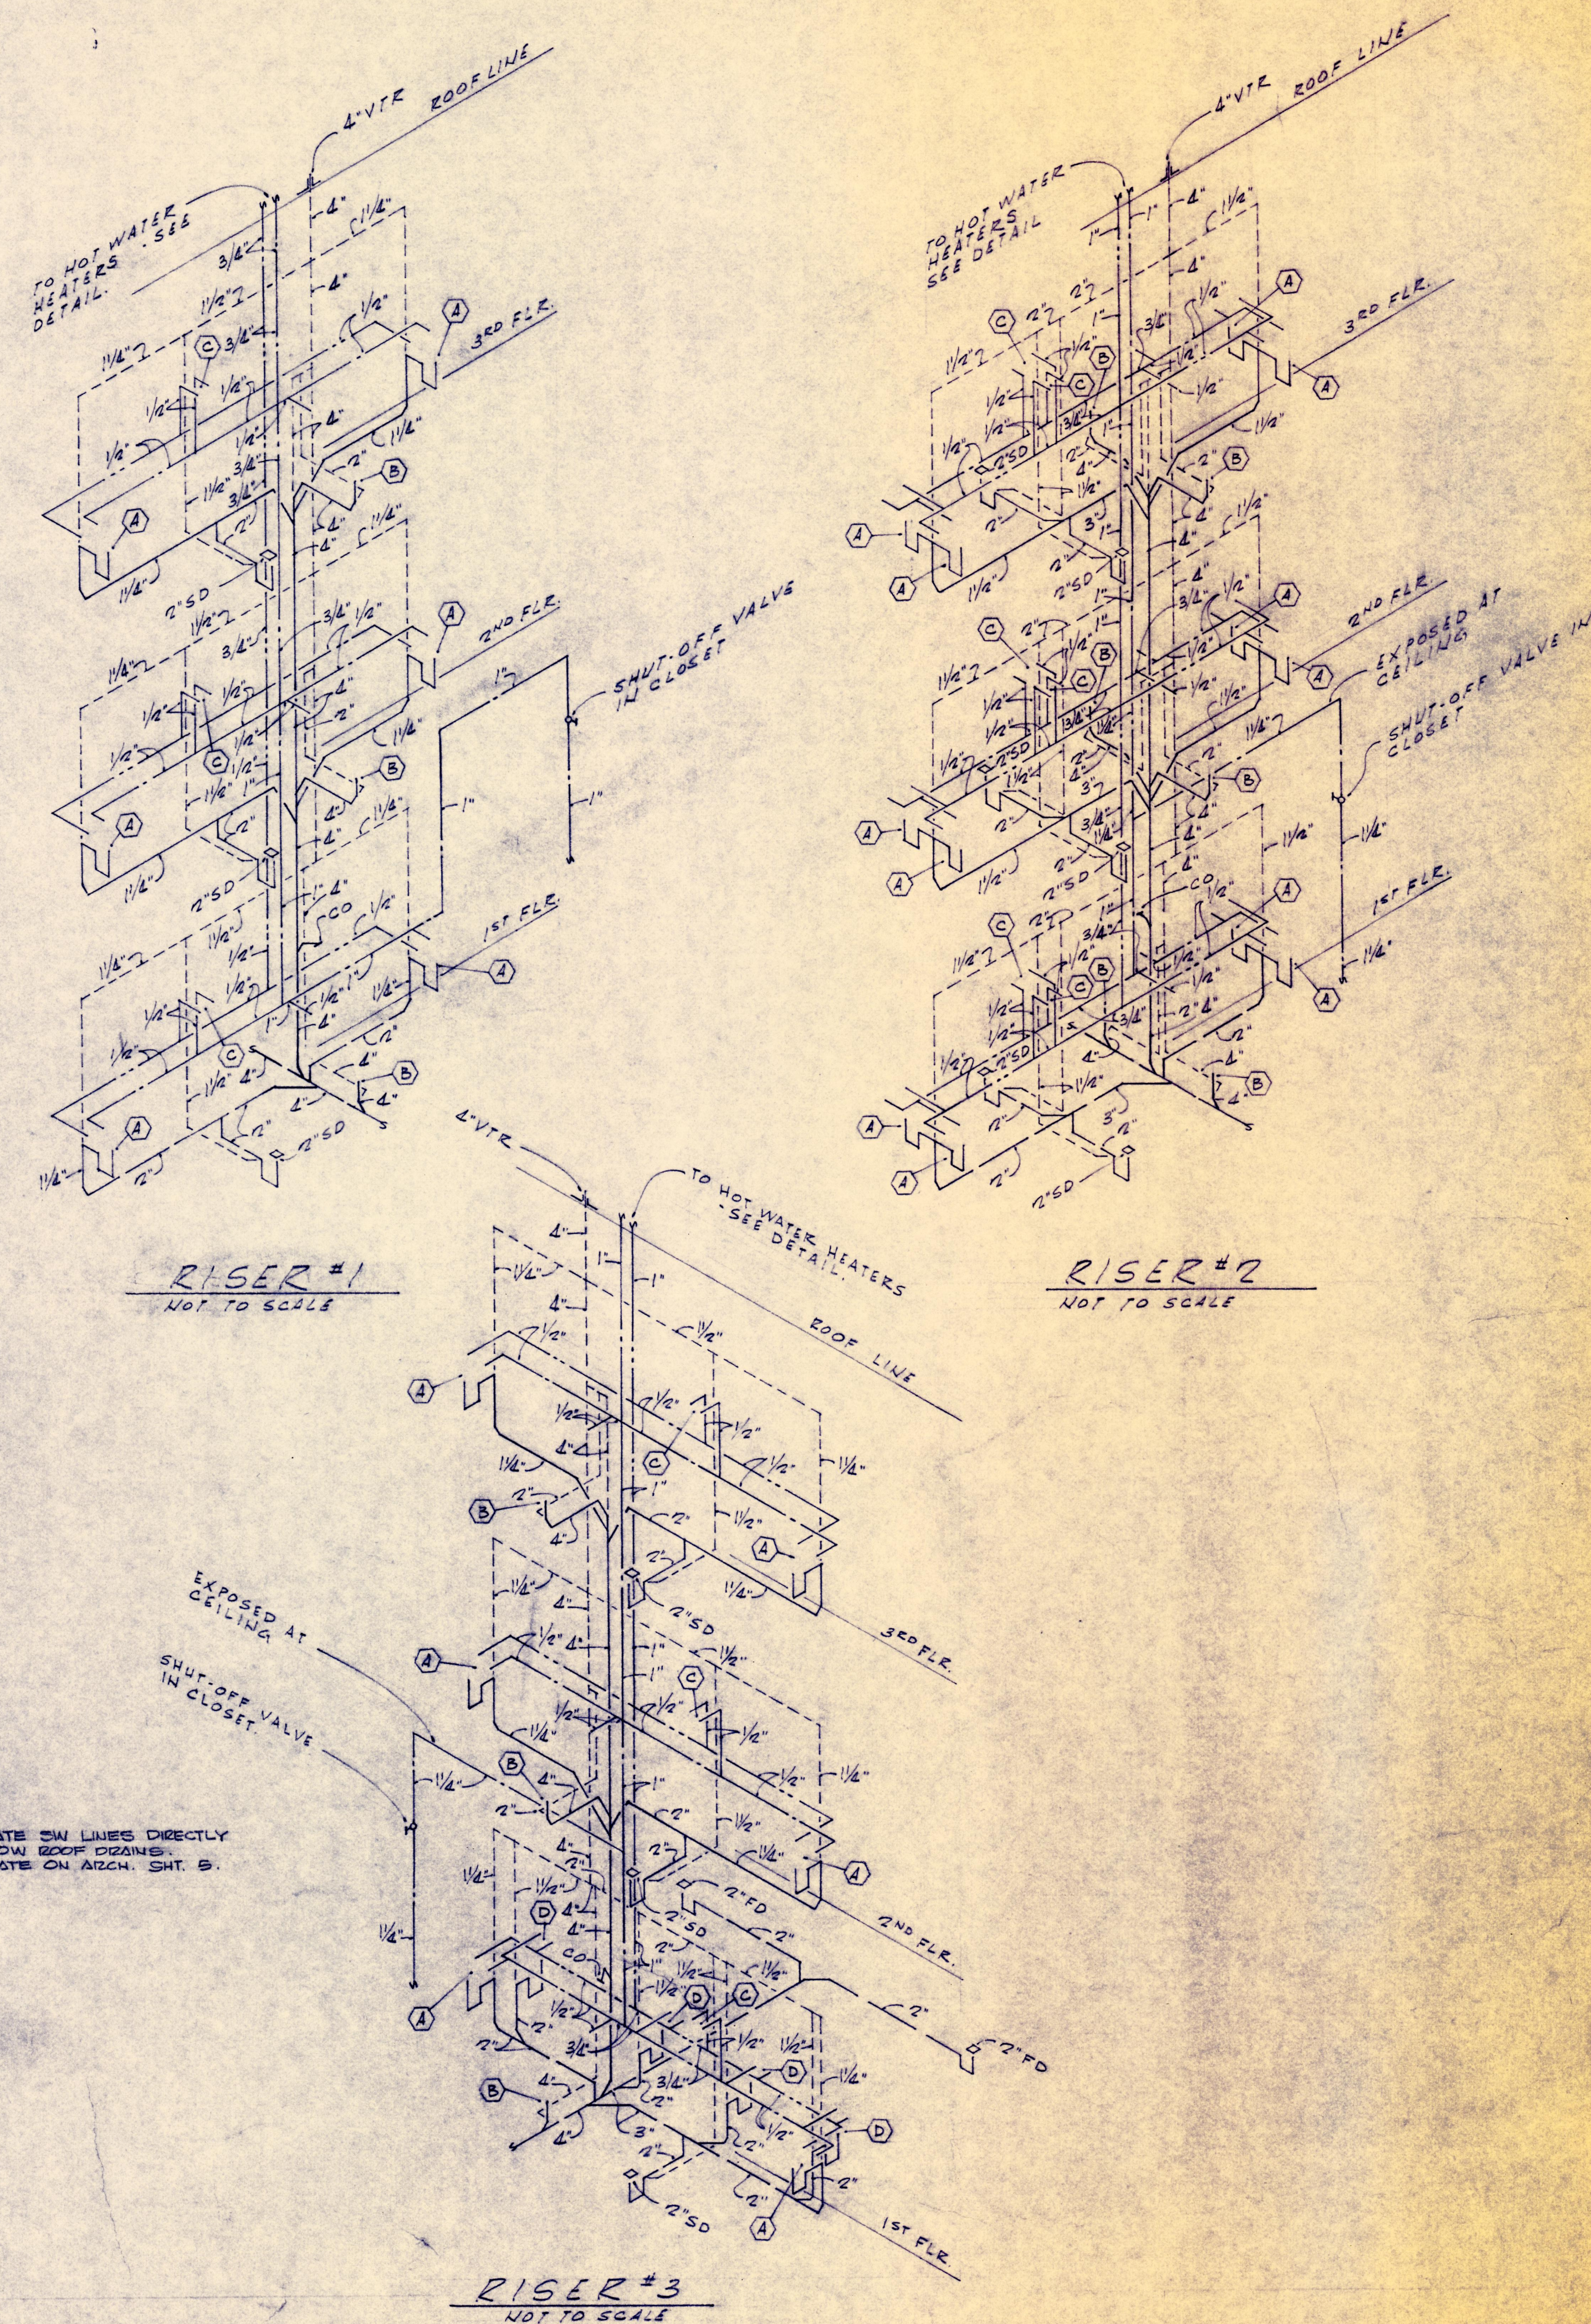


- NOTES:**
1. SEE RISER #1 & TYPICAL TOILET ROOM #1 FOR SIMILAR PIPING LAYOUT & SIZING.
  2. SEE RISER #2 & TYPICAL TOILET ROOM #2 FOR SIMILAR PIPING LAYOUT & SIZING.
  3. SEE RISER #3 & TYPICAL TOILET ROOM #3 FOR SIMILAR PIPING LAYOUT & SIZING.

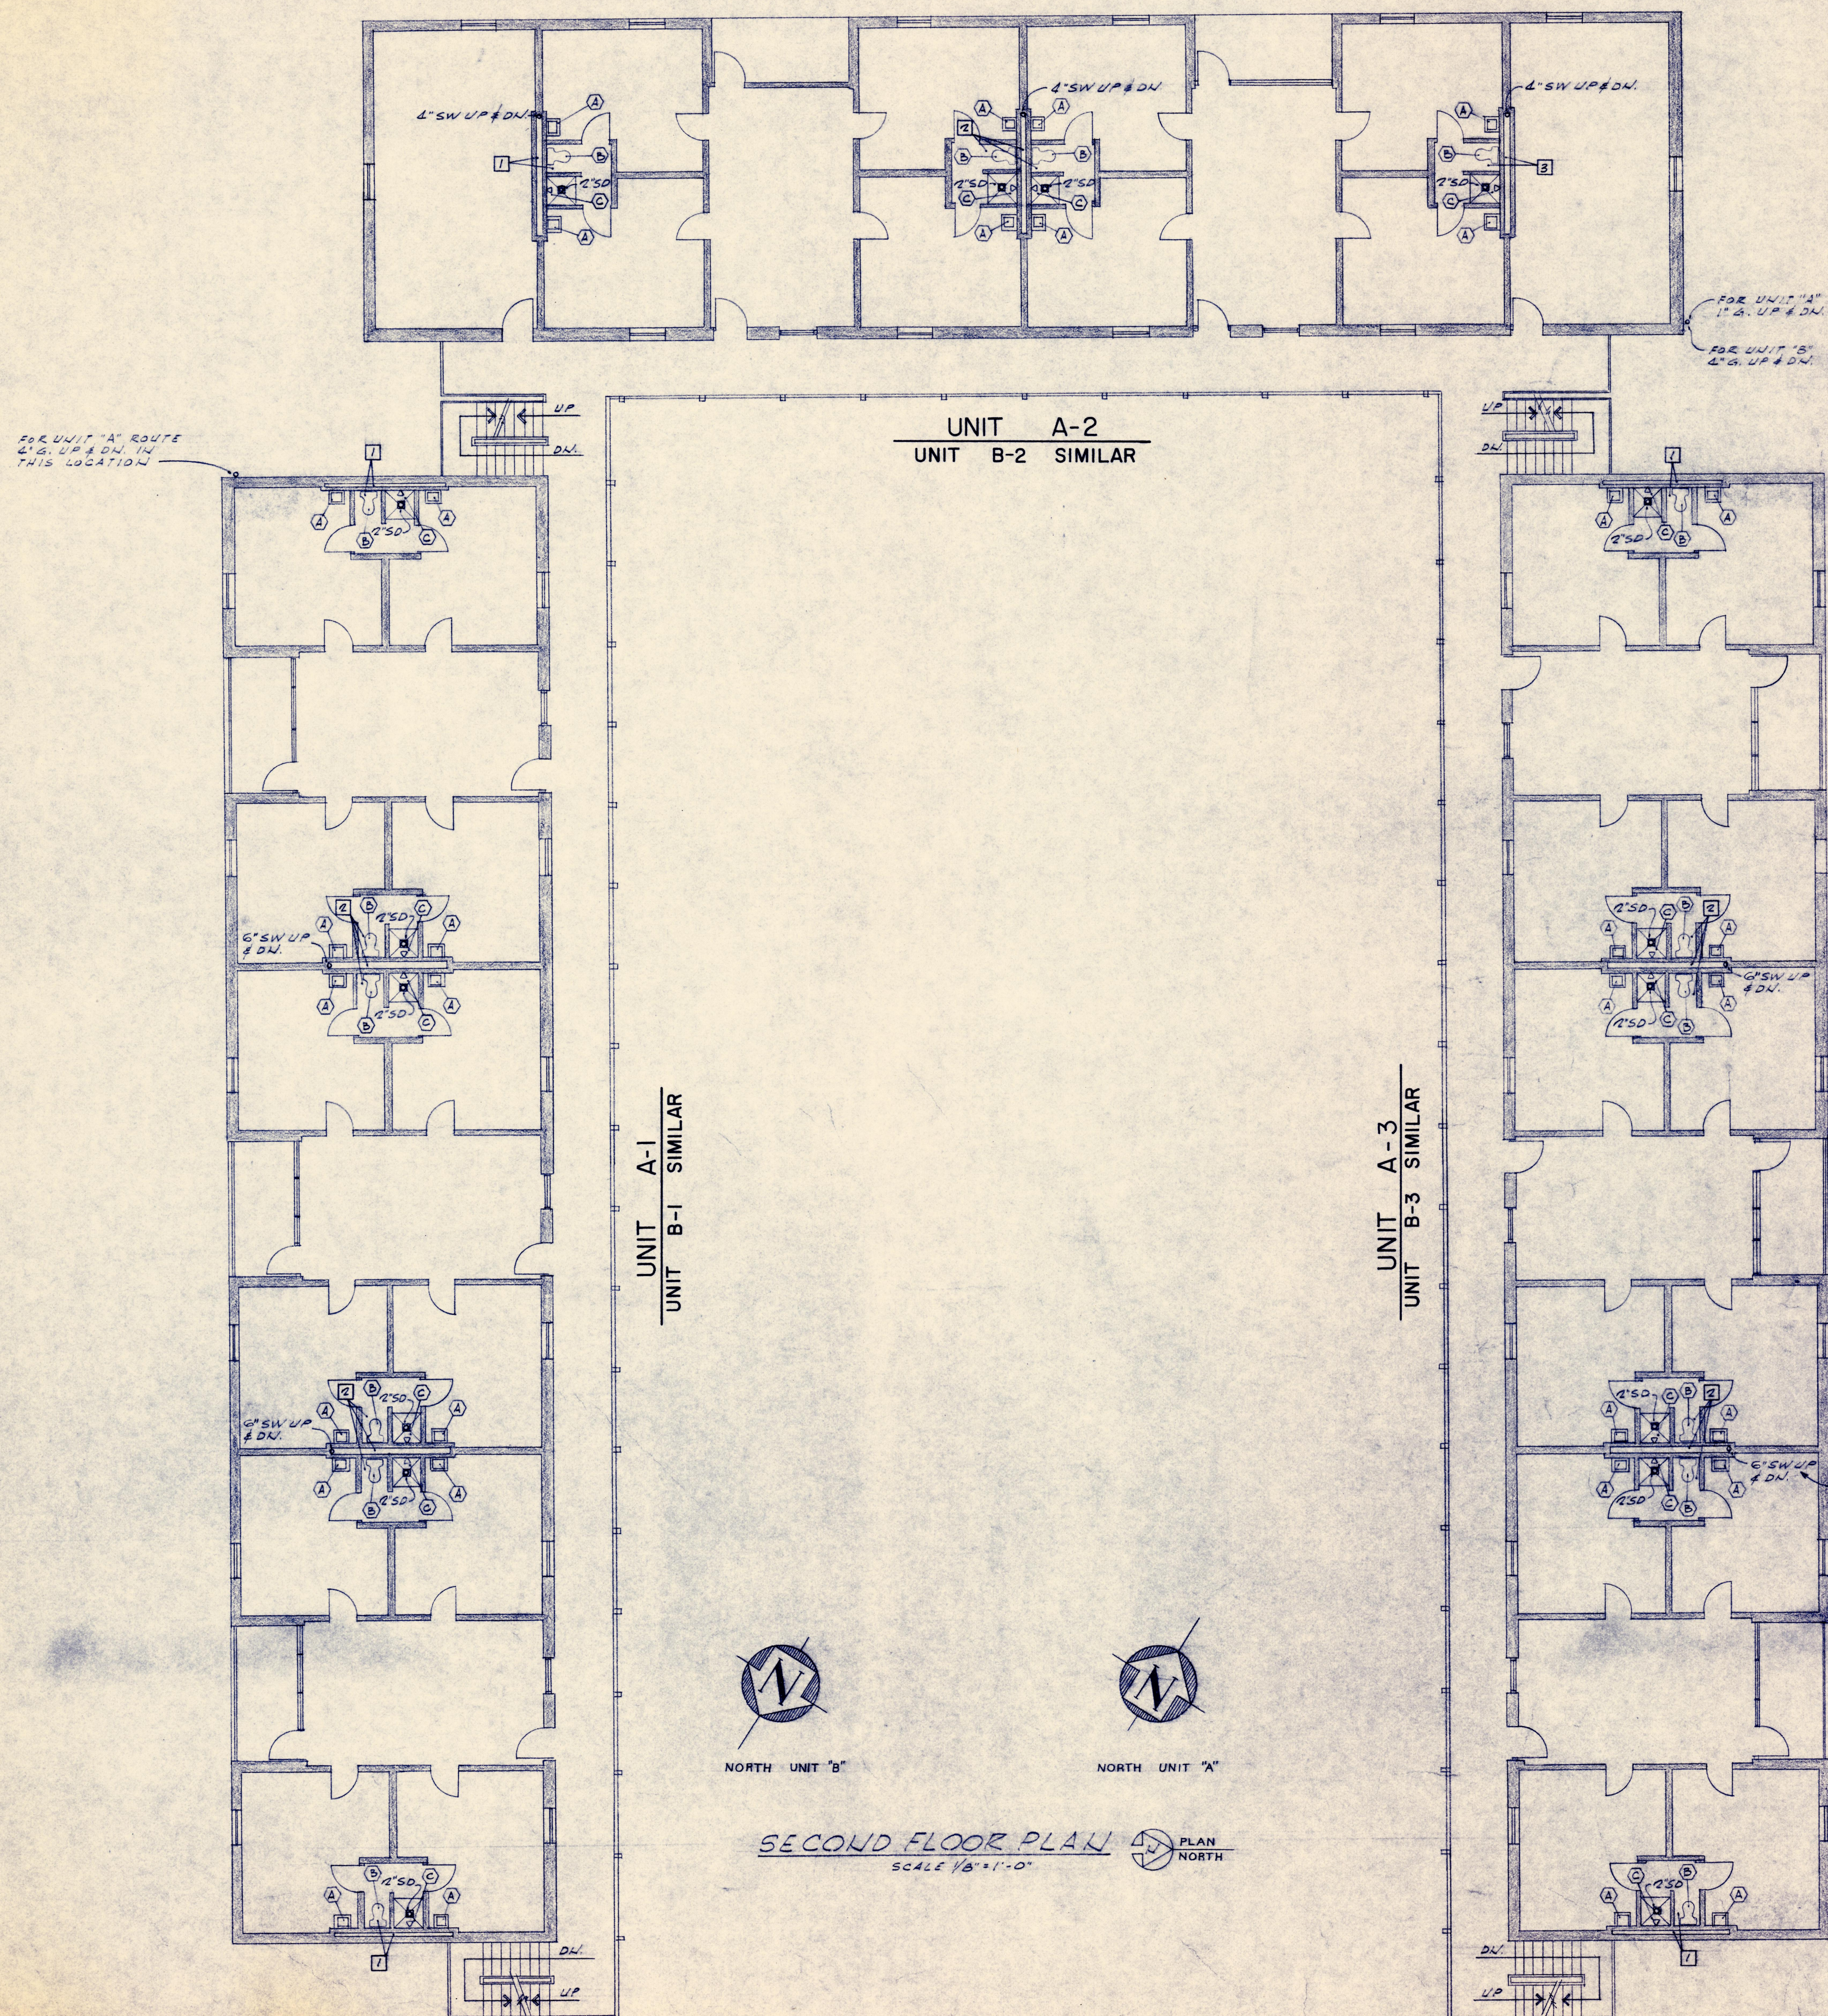

PROJECT NO. CH. MO. 159 (D) 2007.33.2324.P

PLUMBING - SECOND FLOOR PLAN

384 STUDENT DORMITORY  
MISSOURI WESTERN COLLEGE  
ST. JOSEPH, MISSOURI

HERSCHMAN & DOUGLAS  
Architects  
1311 VILLAGE DRIVE - ST. JOSEPH, MISSOURI

MADE BY: E.A.G. CH'KD. BY: H.H.M. REVISED: \_\_\_\_\_

MASSACHUSETTS REGISTERED PROFESSIONAL ENGINEER

SHEET NUMBER  
12-22  
OF 3  
DATE: 8-15-71