


- NOTES:**
- SEE RISER #1 & TYPICAL TOILET ROOM #1 FOR SIMILAR PIPING LAYOUT & SIZING.
 - SEE RISER #2 & TYPICAL TOILET ROOM #2 FOR SIMILAR PIPING LAYOUT & SIZING.
 - SEE RISER #3 & TYPICAL TOILET ROOM #3 FOR SIMILAR PIPING LAYOUT & SIZING.

PLUMBING SYMBOLS

- CW COLD WATER
- HW HOT WATER
- W WASTE ABOVE GROUND
- W WASTE BELOW GROUND
- VCP VITRIFIED CLAY PIPE
- V VENT LINE
- SW SW STORM WATER ABOVE GROUND
- SW SW STORM WATER BELOW GROUND
- C/WO CLEANOUT IN WALL
- C/FD CLEANOUT IN FLOOR
- GATE VALVE
- UNION
- WH WALL HYDRANT
- RD ROOF DRAIN
- FD FLOOR DRAIN
- VTE VENT THRU ROOF
- G GAS LINE
- STOP COCK
- S.D. SHOWER DRAIN IN TERRAZZO RECEPTOR - FURNISH TRAP & CONNECT UP

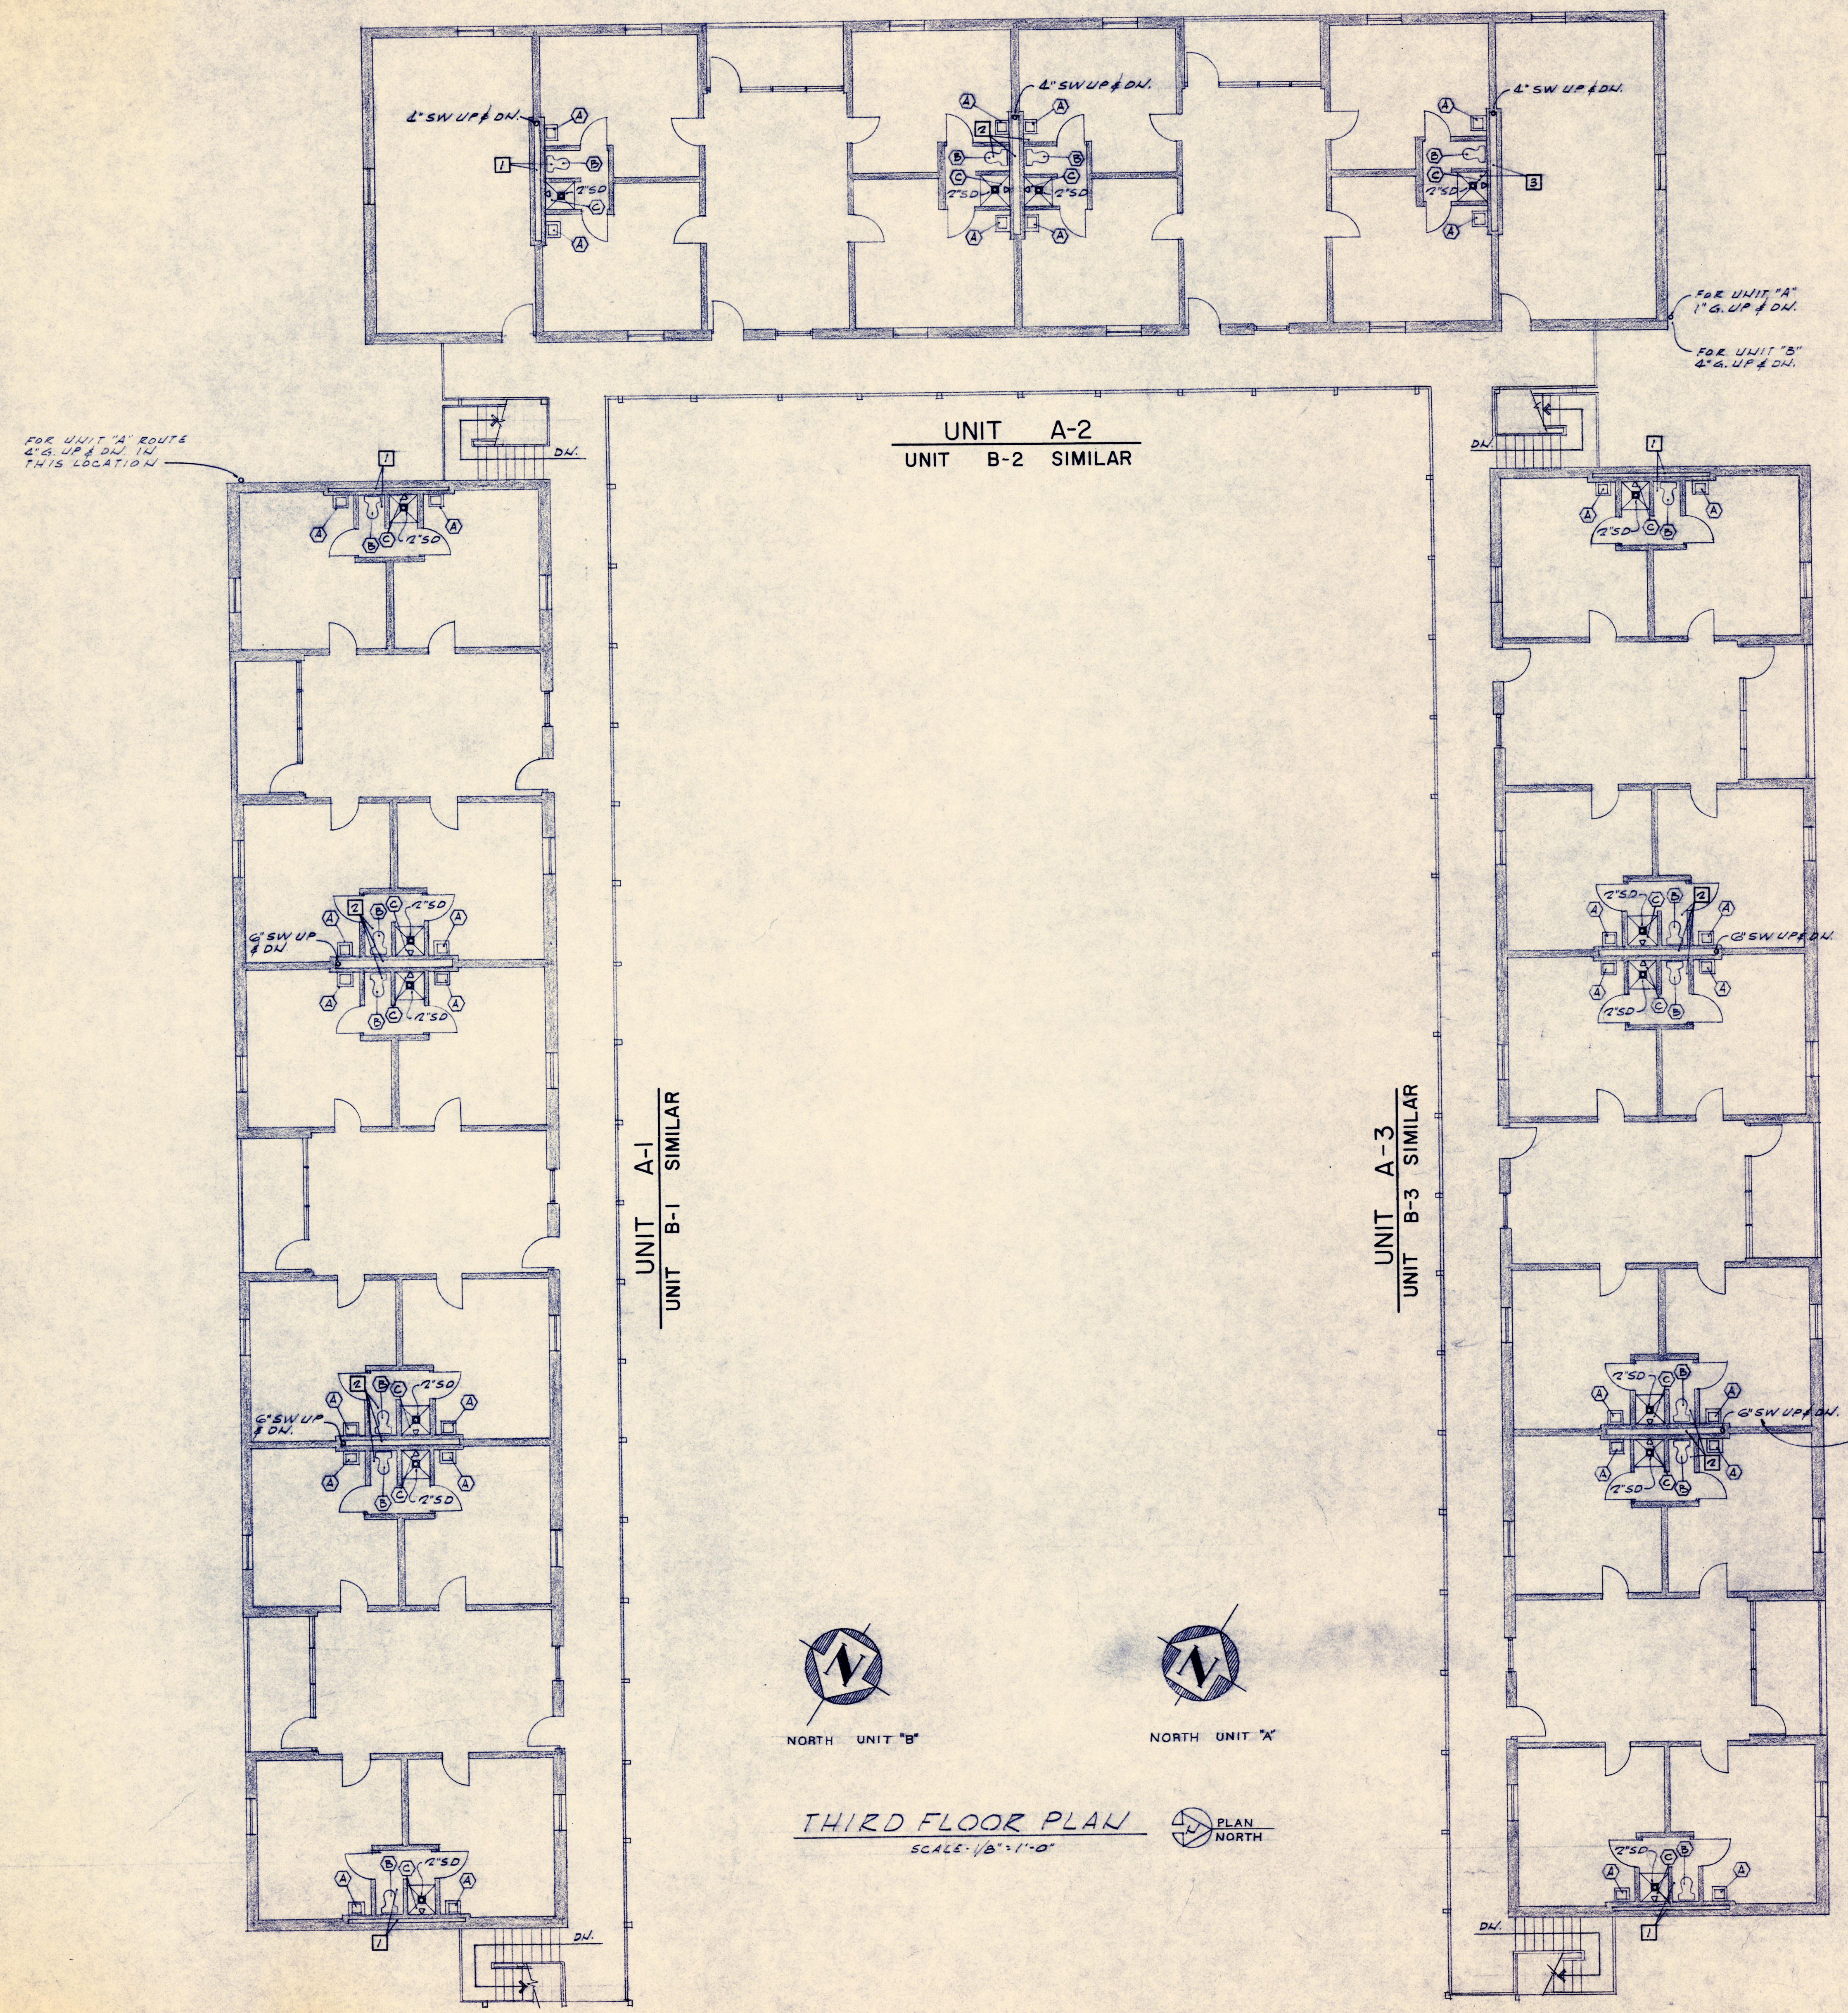

THIRD FLOOR PLAN
SCALE: 1/8" = 1'-0"

PROJECT NO. CH MO 159 (C) 2007.33.2321.0

PLUMBING - THIRD FLOOR PLAN

	384 STUDENT DORMITORY				SHEET NUMBER P-33 OF 3 DATE: 8-15-71
	MISSOURI WESTERN COLLEGE				
	ST. JOSEPH, MISSOURI				
	DR. M. J. LOONEY, PRESIDENT				
HERSCHMAN		DOUGLAS			
Architects		Engineers			
1311 VILLAGE DRIVE — ST. JOSEPH, MISSOURI					
MADE BY: R.A.C.	CH'D BY: H.H.M.	REVISED:			
MAGAGLIA • NEUSTROM • MIDDLETON MECHANICAL ENGINEERS					