


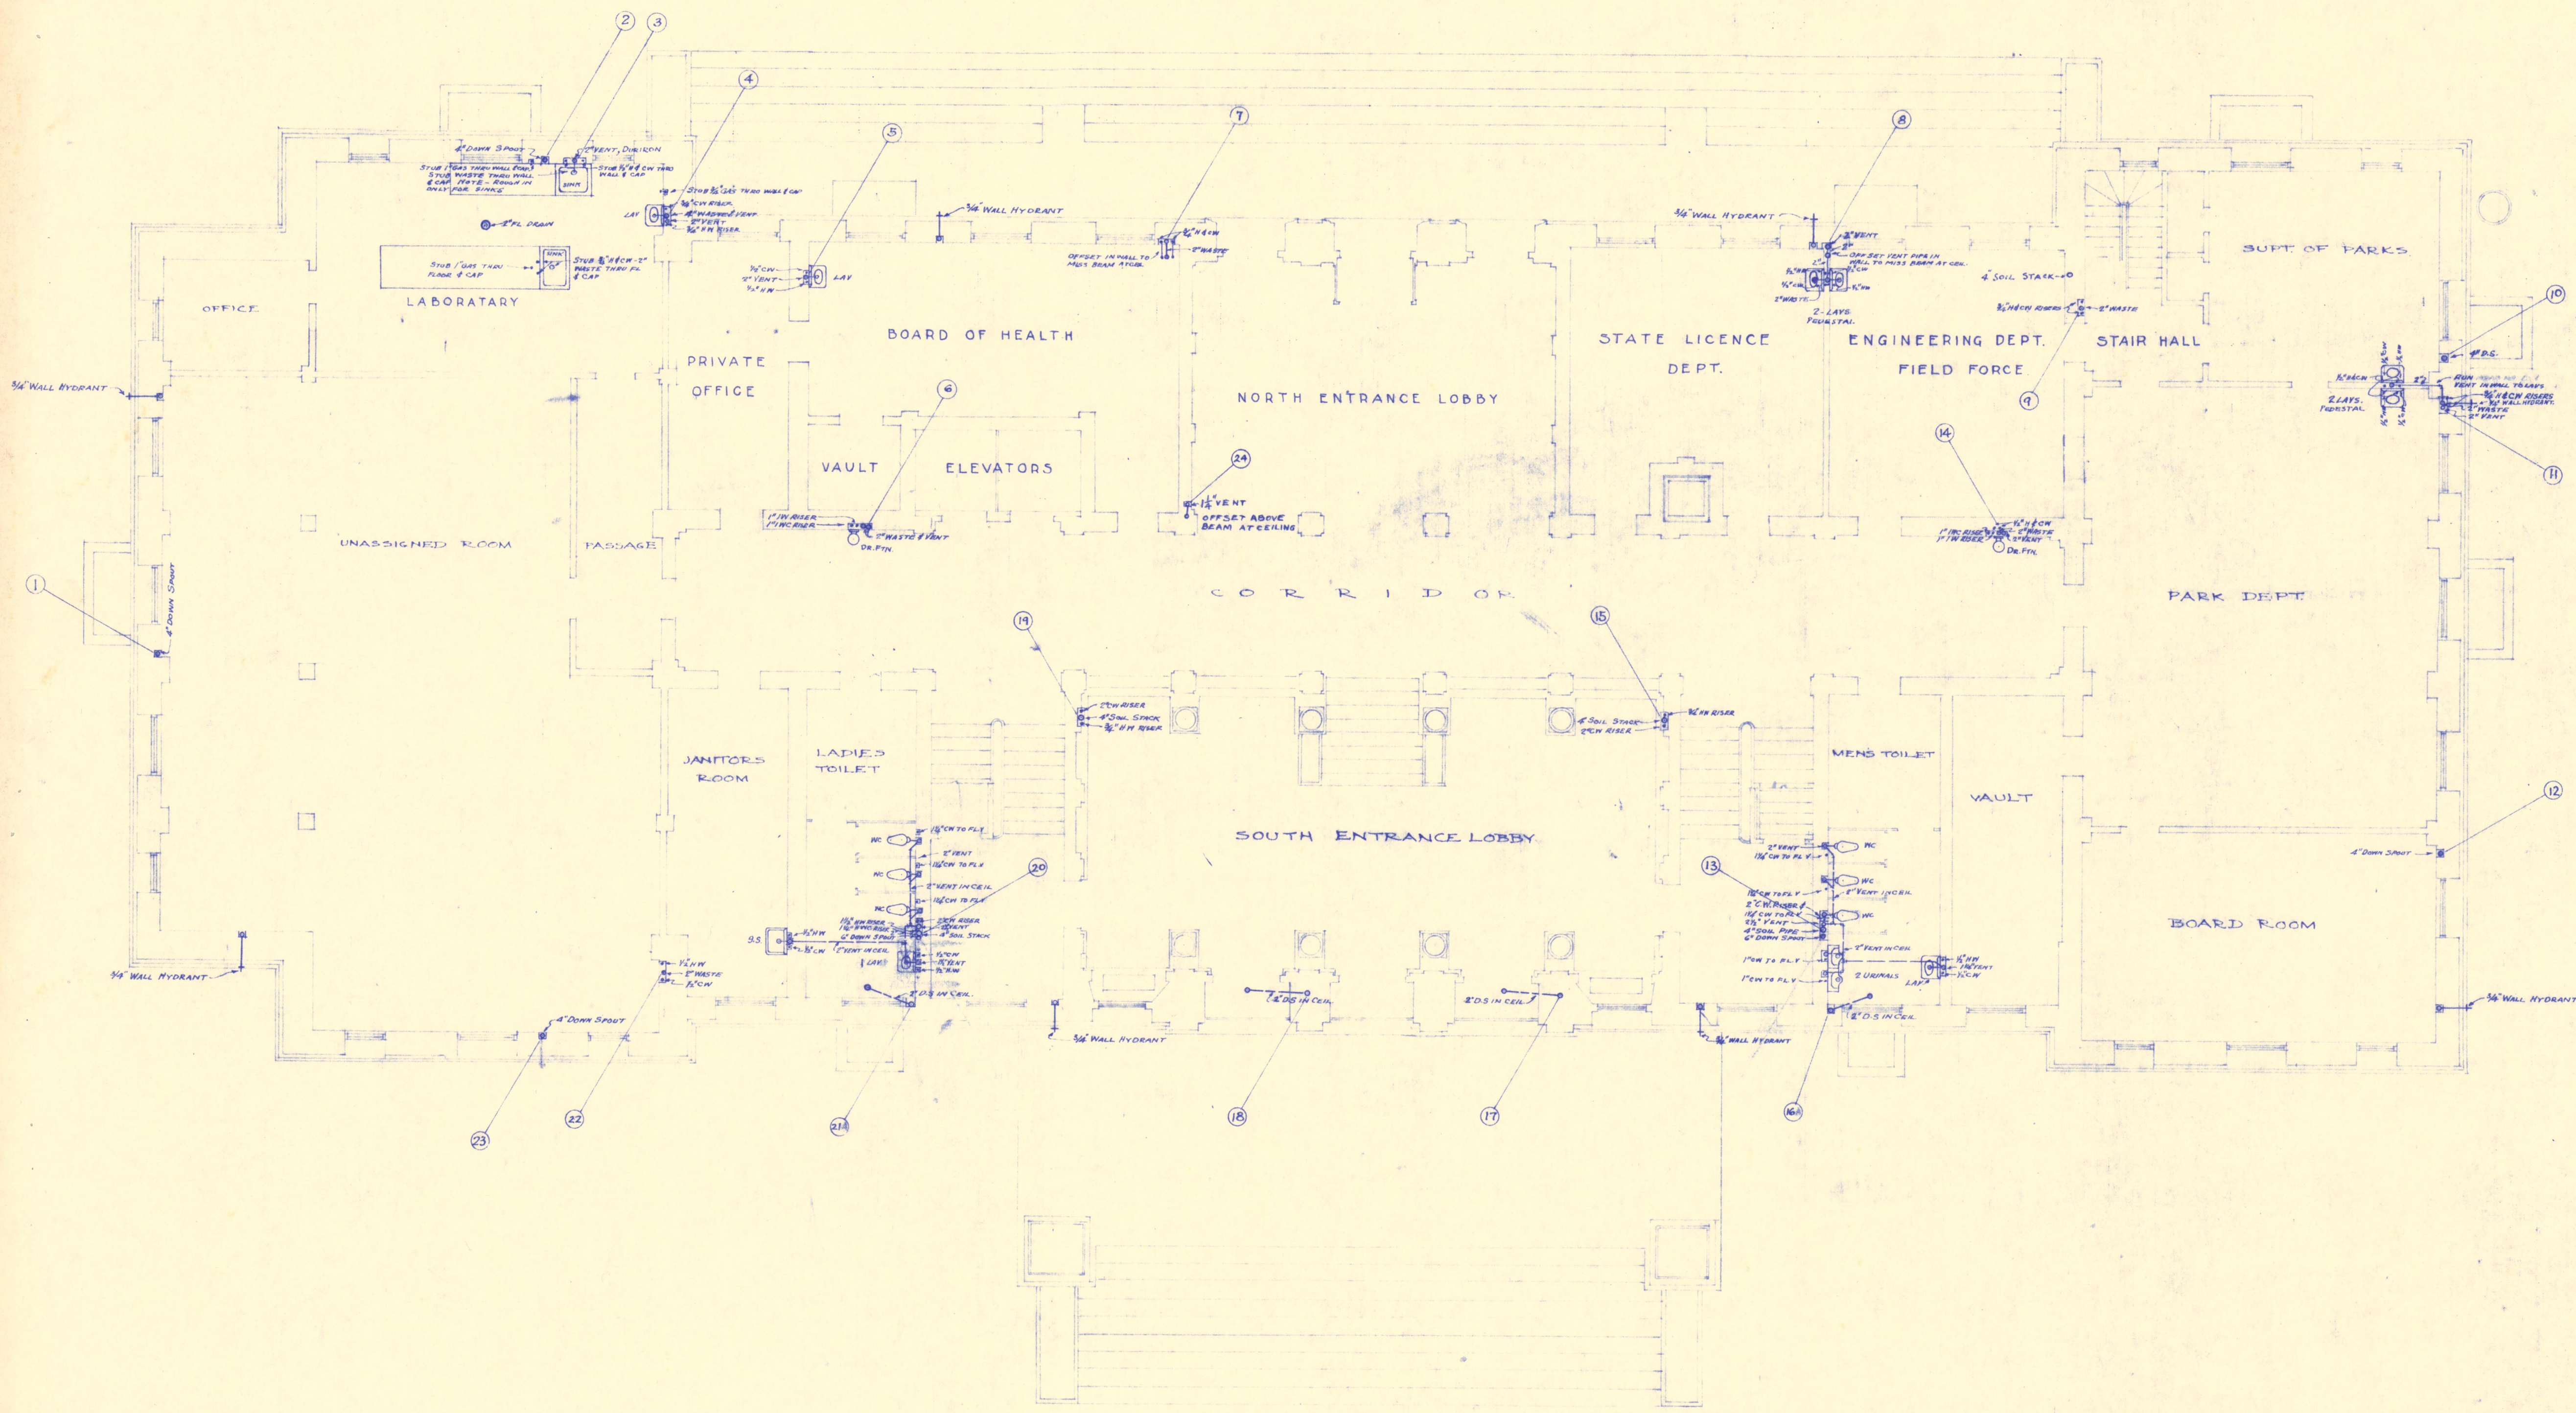

SCALE 1/8" = 1'-0"
GROUND FLOOR PLAN

PLUMBING AND DRAINAGE		
~ CITY HALL ~ ST. JOSEPH, MISSOURI.		
DATE JUNE 22, 1925	ECKEL AND ALDRICH ARCHITECTS ST. JOSEPH, MO. LOS ANGELES	SHEET 303
2007.33.42/9		